



**WARNING:**  
This document is the property of the U.S. Government. Further reproduction and/or distribution is prohibited without the express written permission of:  
FOREIGN BUILDING OPERATIONS  
U.S. Department of State, Washington, DC, 20522-0620  
Information on this document is not to be altered except with the written approval of the individual whose seal appears hereon.

**SENSITIVE  
BUT  
UNCLASSIFIED**

Engineer



25th Floor Chatham House 116 Valero cor.  
V.A. Rufino St. Salcedo Village, Makati City  
Tele. (632) 887-1391 E-mail mpi@meinhardt.com.ph  
Fax (632) 887-1172

**ALFREDO G. RODRIGUEZ**  
PROFESSIONAL ELECTRICAL ENGINEER

PRC Reg. No: 2633 PTR No: 3178287

Date: JANUARY 04, 2012 Place: MAKATI CITY

APPROVED BY :			
DISCIPLINE	INITIAL	SIGNATURE	DATE
SFM	PLS		
DFM	RLW		
CIVIL/STRL			
ELECTL			
MECHL			

RevNo	Revision note	Date	Sign.

Project Title

**US EMBASSY  
MAIN CHILLER  
PLANT ADDITION**

Location  
ROXAS BOULEVARD, PHILIPPINES

Release For Construction:  
FMM FMS

SHEET CONTENT  
**ELECTRICAL SERVICES  
ELECTRICAL POWER LAYOUT**

Phase  
 CONCEPT  35%  60%  90%  100%  FINAL


Date 29OCT12 CADD File Name

Designed JSS Drawn By JMM

Checked AGR Drawing Number E1-01

Project Number MP1044 Sheet Number 2 of 5

Contract No.

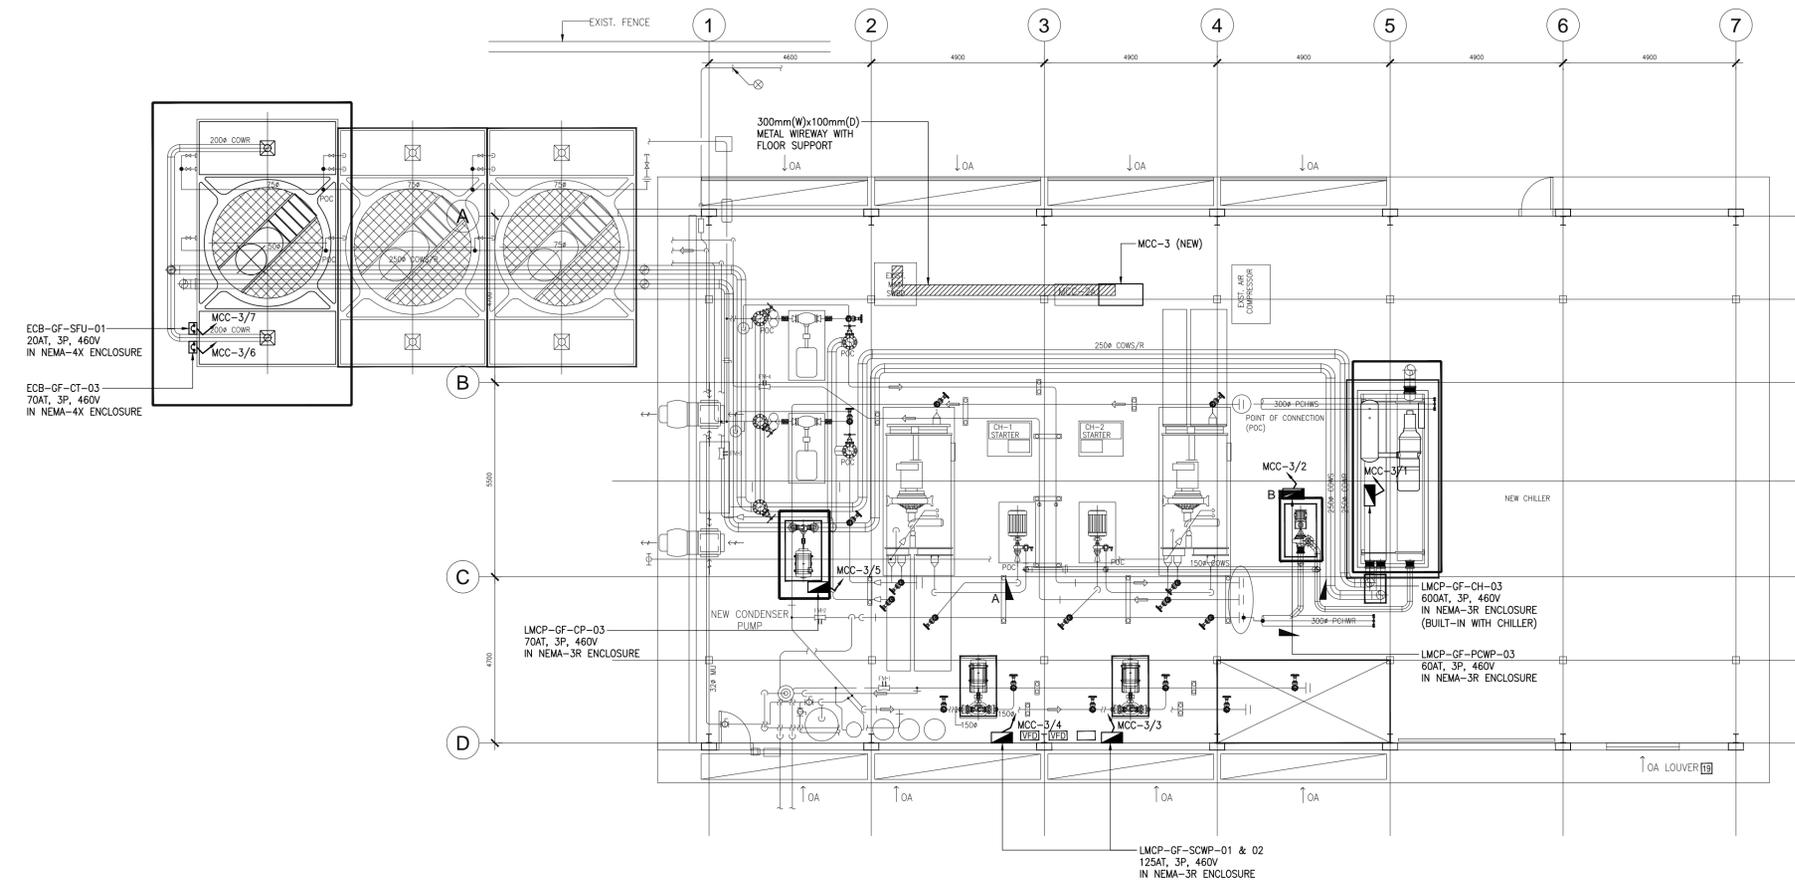

**1 ELECTRICAL POWER LAYOUT**  
E1-01 SCALE 1:100