



**WARNING:**  
Unauthorized release of this information to the public is prohibited without the express written permission of:  
FOREIGN BUILDING OPERATIONS  
U.S. Department of State, Washington, DC 20522-0820  
Information on this project may be used in cooperation with the media. If you are a member of the media, please contact the media relations office for more information.

**SENSITIVE  
BUT  
UNCLASSIFIED**

Engineer  
**MENYARDT**  
25th Floor Chatham House 116 Valero cor.  
V.A. Rufino St., Salcedo Village, Makati City  
Tel: (632) 887-1391 E-mail: mny@menyardt.com.ph  
Fax: (632) 887-1172

OSCAR V. RELUCIO  
PROFESSIONAL MECHANICAL ENGINEER

PROJ. REG. NO.: 2886 PTR. NO.: 3178285

Date: JANUARY 04, 2012 Place: MAKATI CITY


APPROVED BY:	DISCIPLINE	INITIAL	SIGNATURE	DATE
	SFM	PLS		
	DFM	RLW		
	CIVIL/STRL			
	ELECTL			
	MECHL			

Rev/No	Revision Note	Date	Sign.


**US EMBASSY  
MAIN CHILLER  
PLANT ADDITION**

Location  
ROXAS BOULEVARD, PHILIPPINES

Release For Construction:	
SHEET CONTENT	
MECHANICAL SERVICES EXTERNAL CHILLED WATER PIPING LAYOUT & DIFFERENTIAL PRESSURE TRANSMITTER SCHEMATIC DIAGRAM	
Phase	
<input type="checkbox"/> CONCEPT	<input type="checkbox"/> SAS
<input type="checkbox"/> GC	<input type="checkbox"/> IGC
<input type="checkbox"/> FMC	<input type="checkbox"/> FINAL
Date	28OCT12
Designed	ESL
Drawn By	CTE
Checked	JCCOVER
Drawing Number	MZ-02
Project Number	MP1044
Sheet Number	5
of	7
Contract No.	

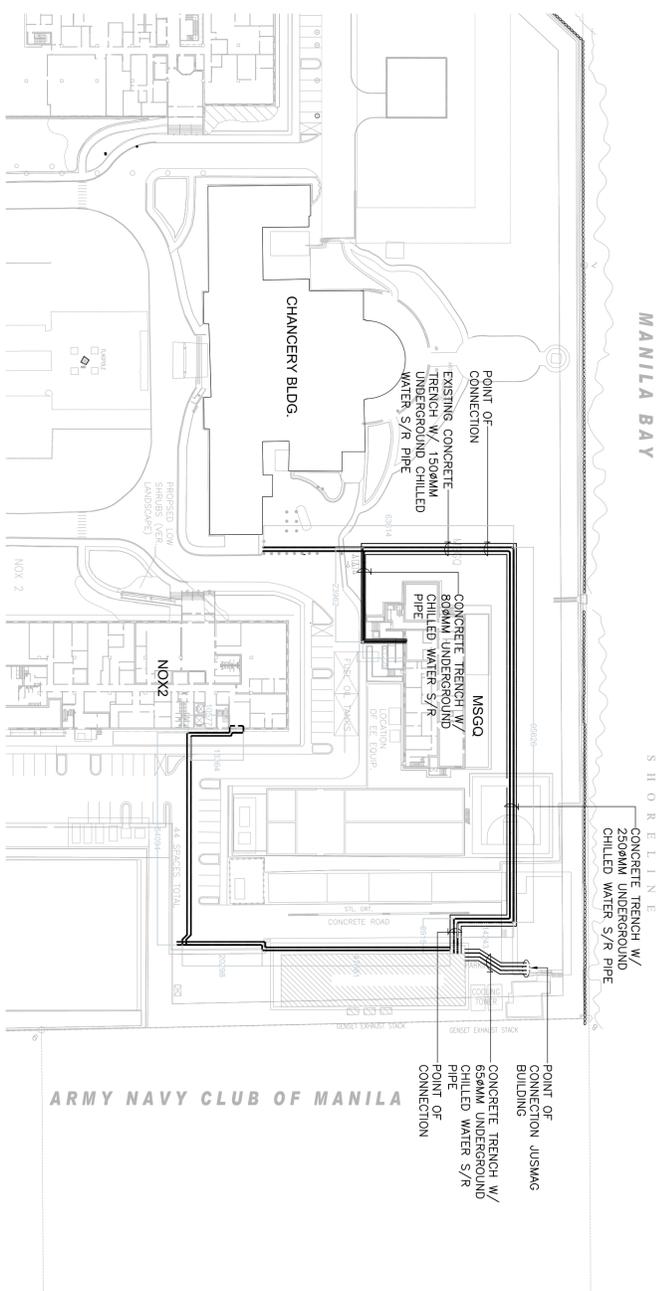

1 EXTERNAL CHILLED WATER PIPING LAYOUT (DRAWING ISSUED BY FMO)

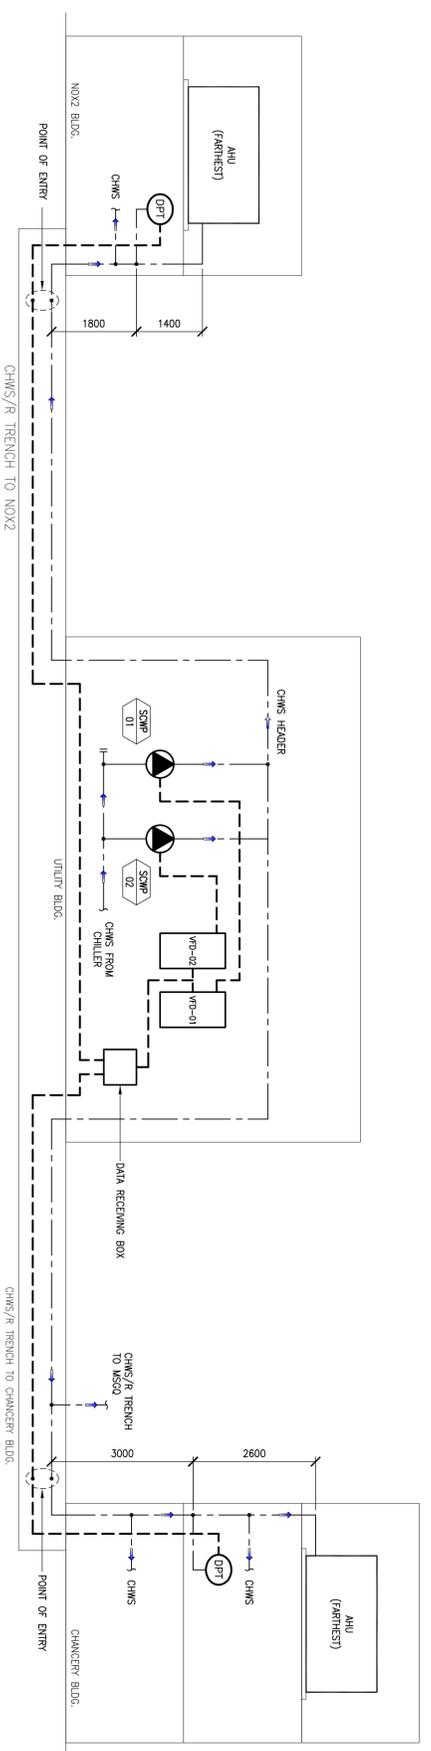

NOTE:  
SUPPLY AND INSTALLATION  
OF CONDUIT BY FMO.

2 INSTALLATION OF DIFFERENTIAL PRESSURE TRANSMITTER (DPT) SCHEMATIC DIAGRAM

FOR TENDER