




WARNING:
This document is the property of the U.S. Government. Further reproduction and/or distribution is prohibited without the express written permission of:
FOREIGN BUILDING OPERATIONS
U.S. Department of State, Washington, DC, 20522-0620
Information on this document is not to be altered except with the written approval of the individual whose seal appears hereon.

**SENSITIVE
BUT
UNCLASSIFIED**

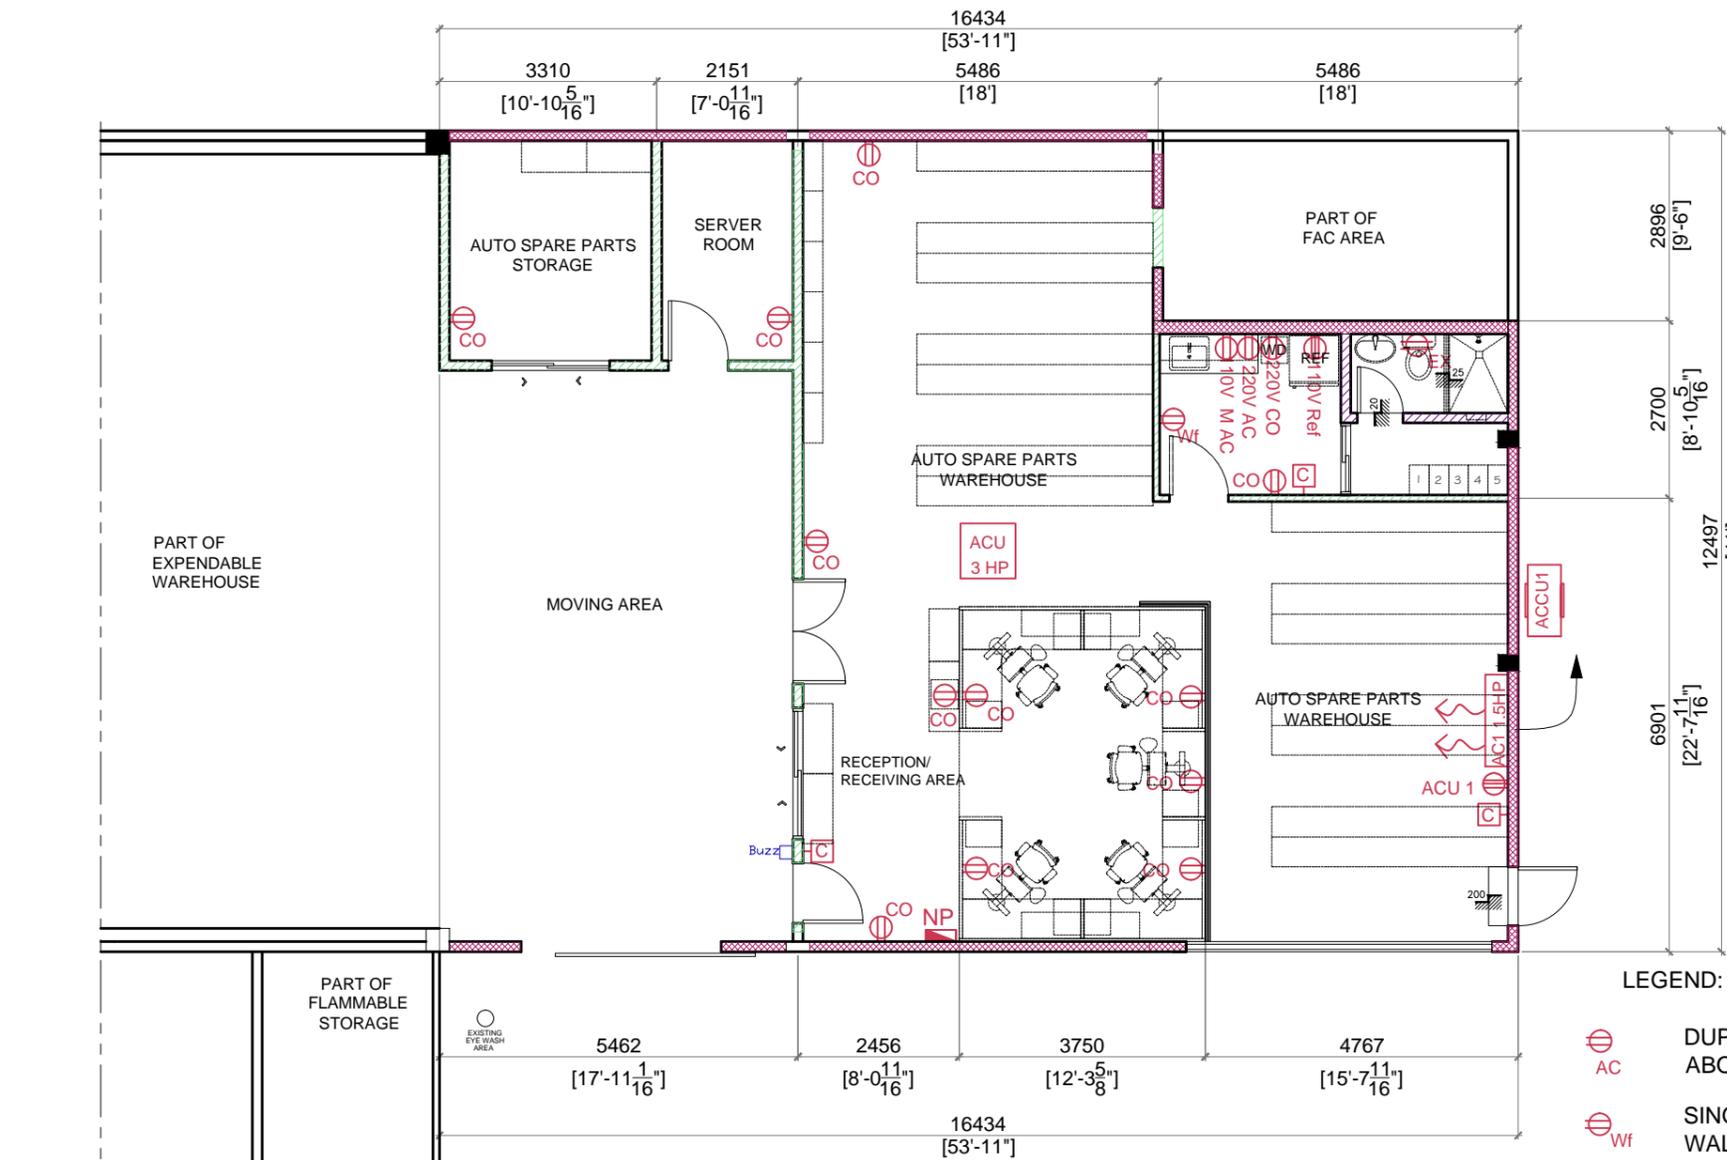

LEGEND:

- AC** DUPLEX CONVENIENCE OUTLET ABOVE COUNTER
- Wf** SINGLE CONVENIENCE OUTLET FOR WALL FAN (VERIFY FINAL HEIGHT)
- Ref** SINGLE CONVENIENCE OUTLET FOR REF 300mm FROM FINISH FLOOR LINE
- CO** DUPLEX CONVENIENCE OUTLET 300mm FROM FINISH FLOOR LINE
- Buzz** BUZZER
- Ch** CHIME
- EX** SINGLE CONVENIENCE OUTLET FOR INDEPENDENT EXHAUST FAN MOTOR INSIDE CEILING
- NP** NEW PANEL BOARD
- ACU** SINGLE WALL CONVENIENCE OUTLET FOR AIR-CONDITIONING UNIT (VERIFY HEIGHT)

**P&S EXPENDABLE WAREHOUSE
POWER LAYOUT**
SCALE 1:100 M

NOTE:
VERIFY ACTUAL
DIMENSIONS ON SITE

RevNo	Revision note	Date	Sign.

Project Title
**REFURBISHMENT OF
OEXP WAREHOUSE
OFFICE**

Location
**P&S EXPENDABLE
WAREHOUSE BUILDING
SEAFRONT COMPOUND**

Release For Construction:
FMS FMS

SHEET CONTENT

POWER LAYOUT						
Pluse	CONCEPT	35%	60%	90%	100%	FINAL

Date	8-28-15	CADD File Name	
Designed		Drawn By	MJT
Checked	AGM/RPB	Drawing Number	
Project Number		Sheet Number	A-7
Contract No.			