


**UNITED STATES EMBASSY
MANILA, PHILIPPINES**



**FACILITIES MAINTENANCE
OFFICE**

WARNING:
This document is the property of the U.S. Government. Further reproduction and/or distribution is prohibited without the express written permission of:
FOREIGN BUILDING OPERATIONS
U.S. Department of State, Washington, DC, 20522-0620
Information on this document is not to be altered except with the written approval of the individual whose seal appears herein.


**Sensitive But Unclassified
(SBU)**

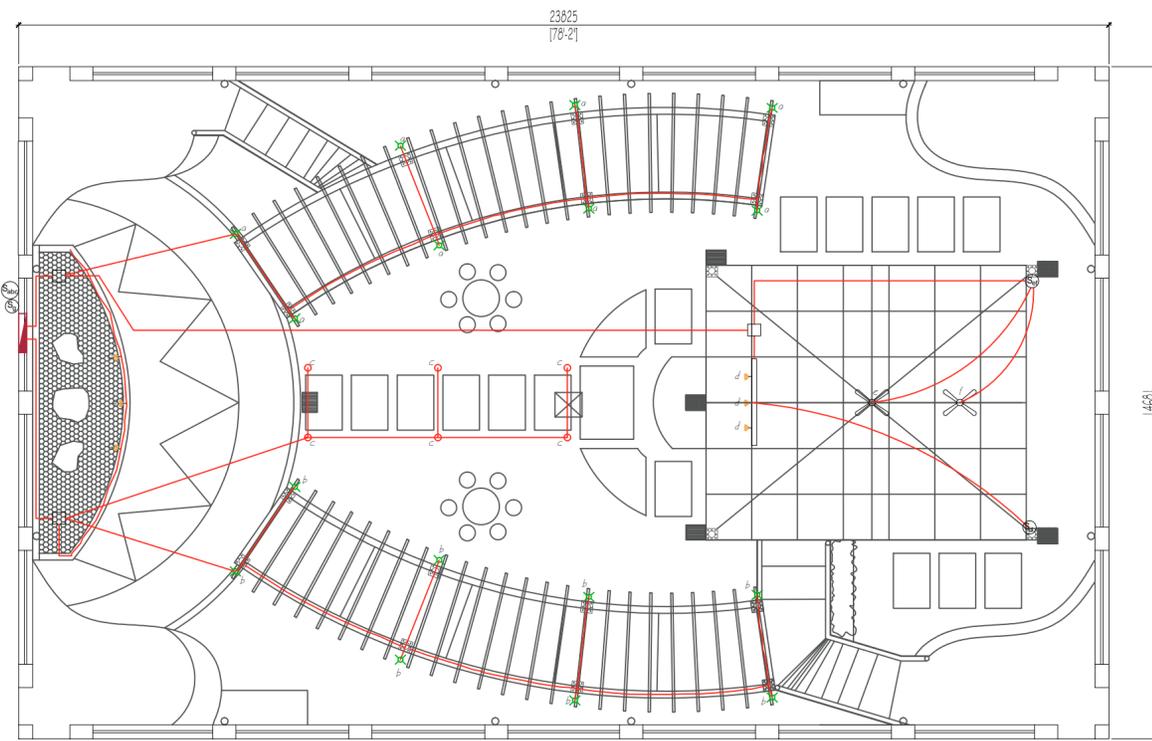

LEGEND:

- LIGHTING POST
- SPOT LIGHT
- SMALL BOLLARD LIGHT

A LIGHTING LAYOUT
E 01 SCALE 1:20 MTS

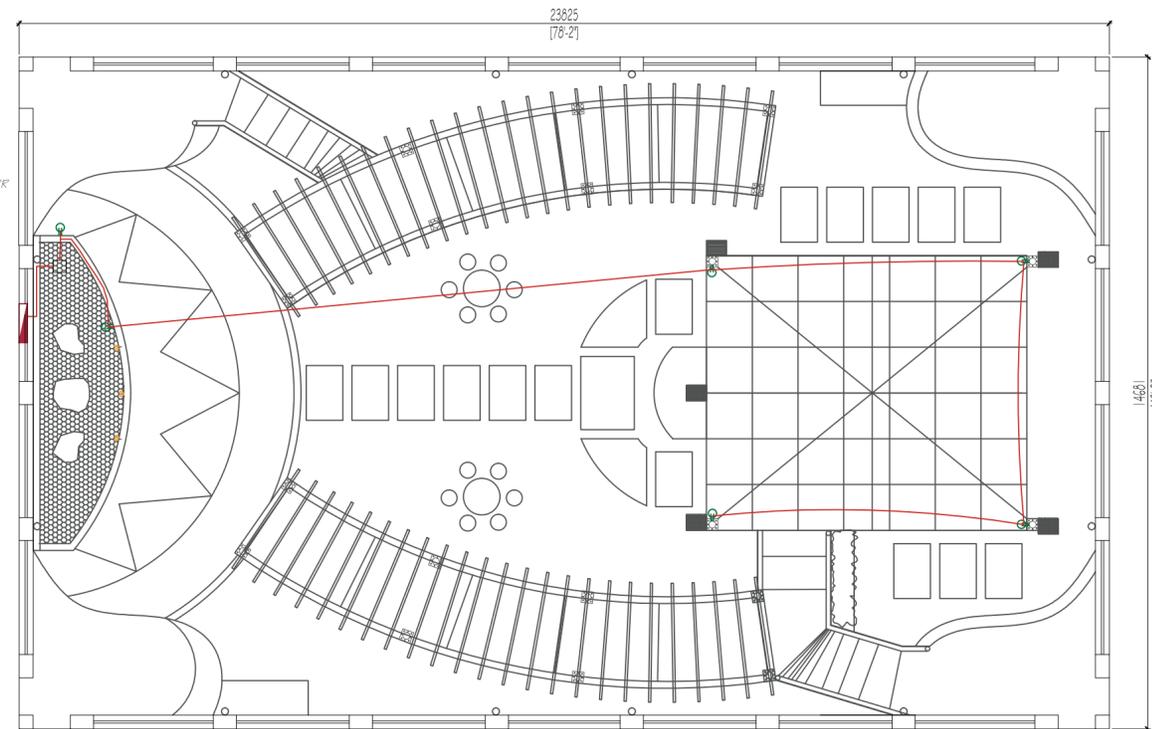

LEGEND:

- POWER OUTLET W/ COVER (WATER PROOF)
- PANEL BOARD
- JUNCTION BOX

B POWER LAYOUT
E 01 SCALE 1:100 MTS

| RevNo | Revision note | Date | Sign. |
|-------|---------------|------|-------|
| | | | |
| | | | |
| | | | |
| | | | |
| | | | |

Project Title
**SEAFRONT COMPOUND
STAFF APARTMENT
(CENTER COURT)**

Location
**REPAIR OF STAFF APARTMENT
CENTER COURT**

Release For Construction:
FMM FMS

SHEET CONTENT
**LIGHTING LAYOUT
AND POWER LAYOUT**

Phase
 CONCEPT 35% 60% 90% 100% FINAL

| | | | |
|----------------|------------|----------------|----------|
| Date | 08/26/2015 | CADD File Name | |
| Designed | | Drawn By | CK |
| Checked | | Drawing Number | E - 01 |
| Project Number | | Sheet Number | 09 of 11 |
| Contract No. | | | |