
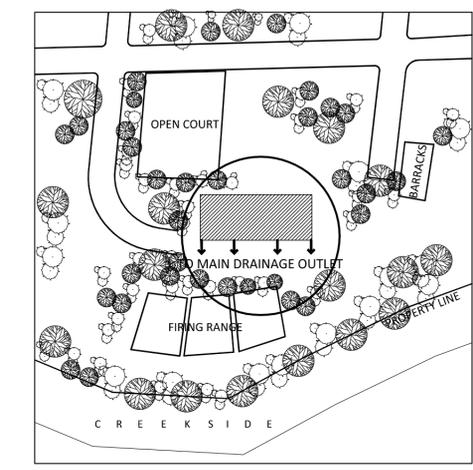
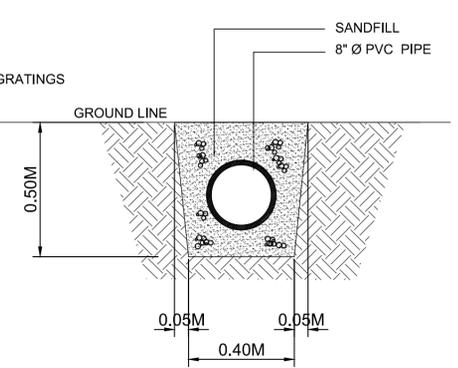
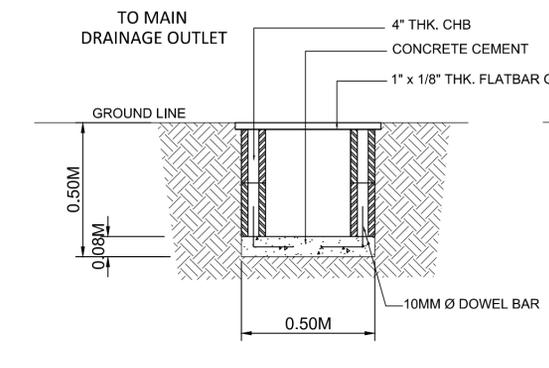


NOTE:
TRENCH DRAIN PROVIDED
@ FRONT & REAR OF THE STRUCTURE

STORM DRAINAGE LAYOUT
SCALE 1: 100 METERS

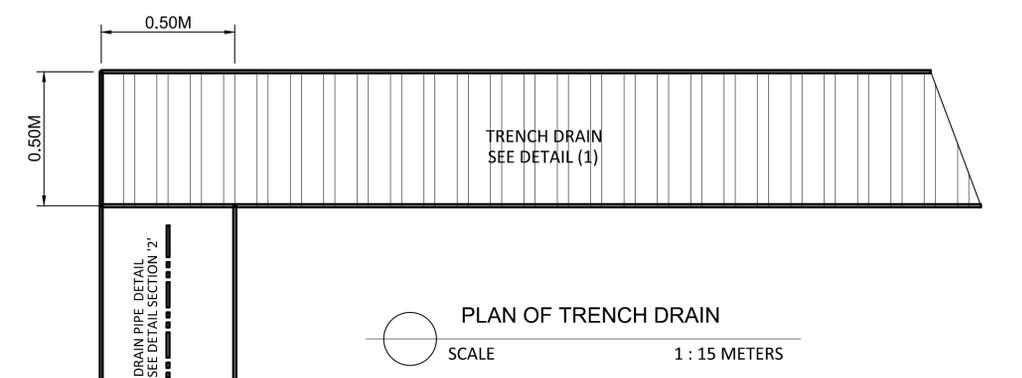

SITE PLAN

PROJECT TITLE :	PREPARED BY:	CHECKED BY:	SUBMITTED BY:	RECOMMEND APPROVAL:	APPROVED BY:	SHEET NO.
PROPOSED PNP SAF CLASSROOMS	ENGR FRENEL B BAUTISTA PCINSP CHIEF, PLANS & DESIGN SECTION	ARCH PAVEL D HALOG PSUPT CHIEF, CONSTRUCTION & REPAIR DIVISION	JOEL FELIX MATEO D RUNES IV, MPA PSSUPT CDS, ENGINEERING SERVICE	JEROME P PAGARAGAN, CEO VI PSSUPT DEPUTY DIRECTOR, ENGINEERING SERVICE	CRISTINO C CAMPANILLA, CESE PCSUPT DIRECTOR, ENGINEERING SERVICE	P-1 JUNE 22, 2012 <small>DATE DRAWING COMPLETED</small>
	LOCATION: FORT STO DOMINGO, STA ROSA, LAGUNA					