



United States Department of State
OFFICE OF OVERSEAS BUILDINGS OPERATIONS
Washington, D.C.

STANDARD RESIDENTIAL
GENERATOR
INSTALLATION DETAILS

Drawing Title

STANDARD
GENERATOR PAD
DETAILS - 33KVA
OR SMALLER




Sheet Number

G1

Date:
9/17/13

NOTES

1. ALL CONCRETE SHALL BE NORMAL WEIGHT AND SHALL ATTAIN THE MINIMUM 28-DAY COMPRESSIVE STRENGTHS OF 25MPa AND 0.45 MAXIMUM W/C RATIOS AND CEMENTITIOUS MATERIALS CONTENT.
2. PROVIDE CLEAR DISTANCE TO OUTERMOST REINFORCING AS FOLLOWS:
CONCRETE CAST AGAINST AND EXPOSED TO EARTH - 75mm
CONCRETE EXPOSED TO EARTH OR WEATHER - 50mm
3. REINFORCING STEEL SHALL BE NEW DEFORMED BILLET STEEL CONFORMING TO A615/615M GRADE 420.
4. SOIL TO BE COMPACTED TO 95% OF ORIGINAL DENSITY. SOIL SHALL BE TREATED TO PROVIDE 100 KPa LOAD BEARING CAPACITY.
5. INSTALL GENERATOR ANCHOR BOLTS IN ACCORDANCE WITH THE MANUFACTURER'S RECOMMENDATIONS.
6. CHAMFER ALL EXPOSED EDGES.
7. FOR GRADE CROSS-SLOPES, THICKEN THE DOWNHILL END OF THE PAD AS REQUIRED TO MAINTAIN THE EMBEDMENT BELOW GRADE SHOWN IN THE DETAIL.
8. PROVIDE FLEXIBLE CONDUIT FROM THE SLAB PENETRATION TO THE GENERATOR CONNECTION BOX. PROVIDE MINIMUM 150mm SLACK CONDUCTORS AT EACH TERMINATION TO ALLOW FOR MOVEMENT IN CASE OF SEISMIC OR OTHER EVENTS.
9. WHERE CONDUIT BLOCKOUTS ARE PROVIDED IN PAD. LOCATE OPENING PER MANUFACTURER'S RECOMMENDATIONS AND CENTER WITHIN THE WIDTH OF THE PAD. THE OPENING SHALL BE (A) NO WIDER THAN 1/3 OF THE PAD WIDTH, (B) NO LONGER THAN 1/2 THE WIDTH OF THE PAD, AND (C) THE OPENING SHALL BE NO CLOSER TO THE END OF THE PAD THAN 1/3 THE WIDTH OF THE PAD OR 300mm.
10. WHERE CONDUIT BLOCKOUTS ARE PROVIDED IN PAD PROVIDE 13mm X 600mm CORNER BARS AS SHOWN. PROVIDE ADDITIONAL 13mm BARS ON EACH SIDE OF THE OPENING AND TIE TO THE BARS CUT FOR THE OPENING. EXTEND BARS ON EACH SIDE A MINIMUM OF 250mm BEYOND THE OPENING AT EACH END. ALL BARS PROVIDED FOR OPENING SHALL BE A MINIMUM OF 50mm FROM THE EDGE OF THE OPENING.
11. PROVIDE TWO 19mm X 3050mm COPPER CLAD STEEL GROUND RODS 3050MM APART. BOND GROUND RODS TOGETHER UTILIZING MECHANICAL GROUND CONNECTORS AND 35mm² BARE COPPER GROUND CONDUCTORS. ROUTE GROUND CONDUCTOR FROM GROUND ROD THROUGH PAD TO BOND TO GROUND LUG ON GENERATOR CHASSIS.

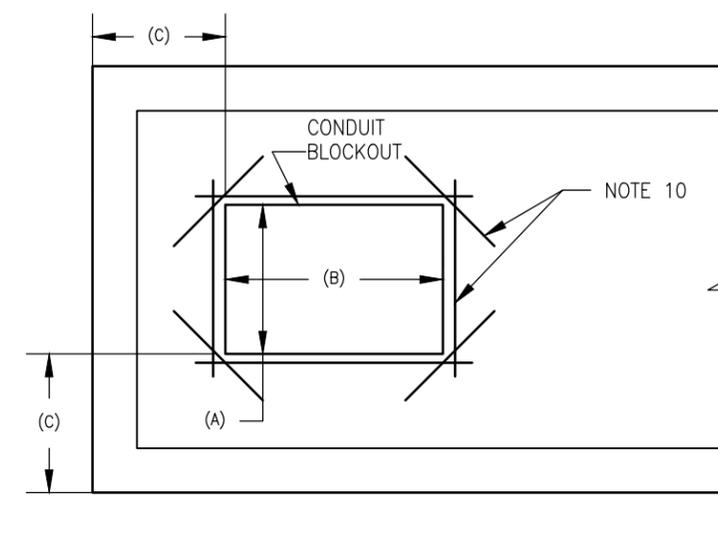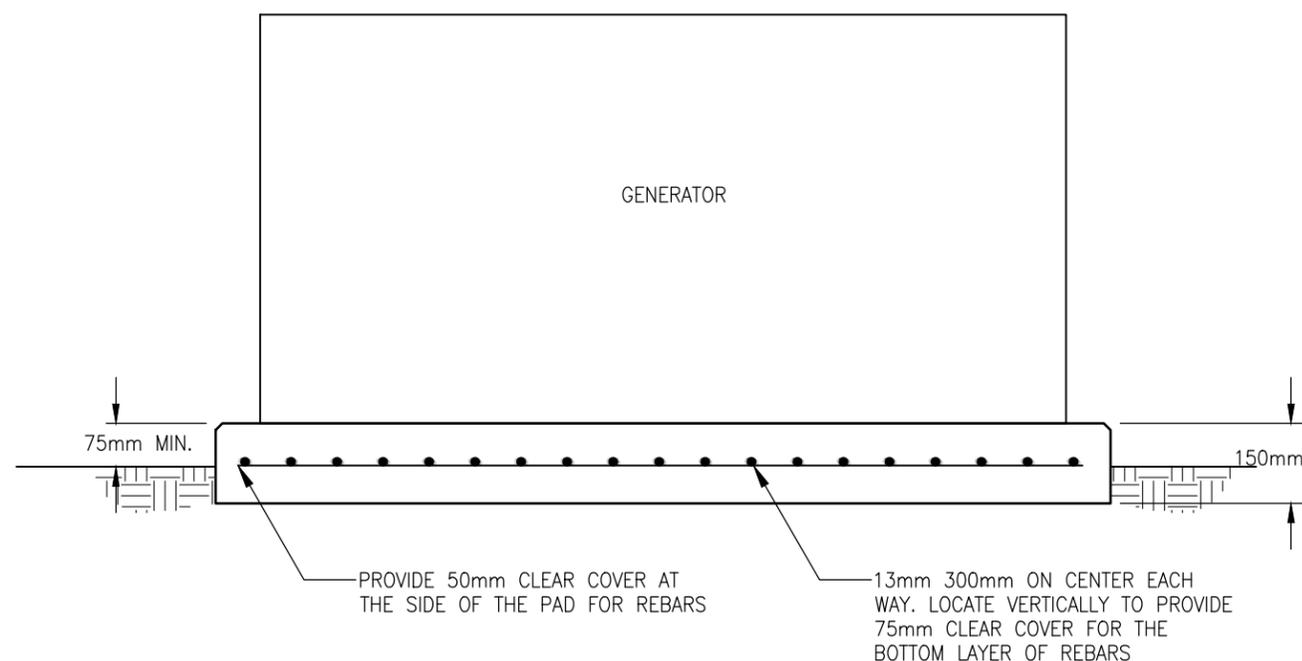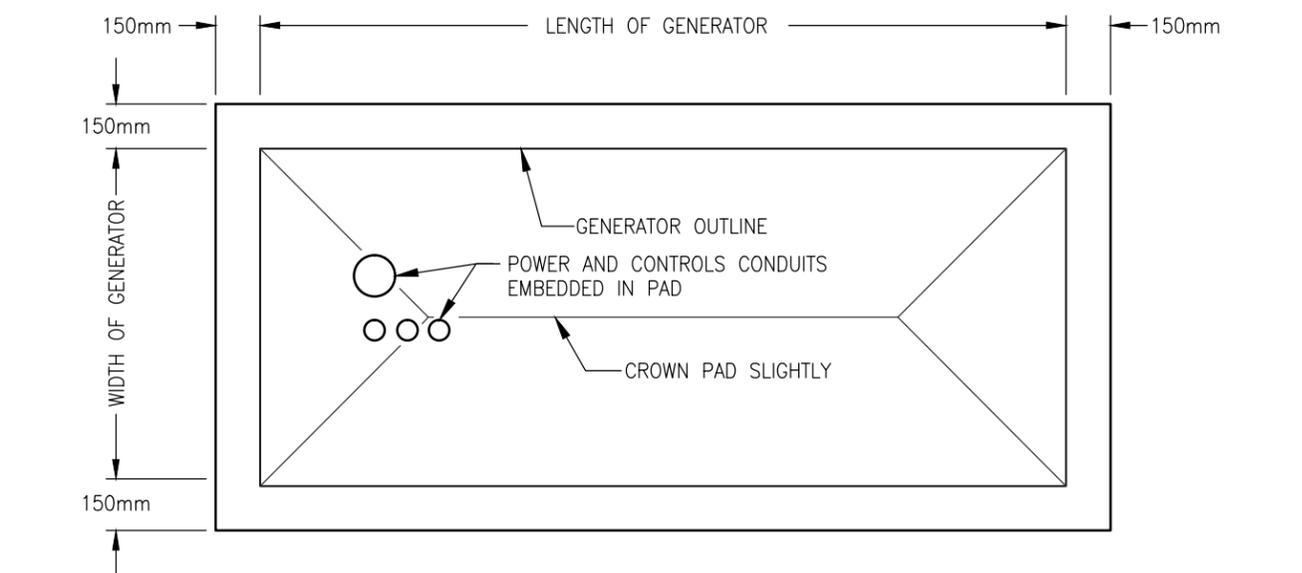

1
G1
33KVA OR SMALLER
GENERATOR PAD DETAIL
SCALE: NTS



United States Department of State
OFFICE OF OVERSEAS BUILDINGS OPERATIONS
Washington, D.C.

STANDARD RESIDENTIAL
GENERATOR
INSTALLATION DETAILS

Drawing Title

STANDARD
GENERATOR PAD
DETAILS - 34KVA
TO 65KVA




Sheet Number

G2

Date:
9/17/13

NOTES

1. ALL CONCRETE SHALL BE NORMAL WEIGHT AND SHALL ATTAIN THE MINIMUM 28-DAY COMPRESSIVE STRENGTHS OF 25MPa AND 0.45 MAXIMUM W/C RATIOS AND CEMENTITIOUS MATERIALS CONTENT.
2. PROVIDE CLEAR DISTANCE TO OUTERMOST REINFORCING AS FOLLOWS:
CONCRETE CAST AGAINST AND EXPOSED TO EARTH - 75mm
CONCRETE EXPOSED TO EARTH OR WEATHER - 50mm
3. REINFORCING STEEL SHALL BE NEW DEFORMED BILLET STEEL CONFORMING TO A615/615M GRADE 420.
4. SOIL TO BE COMPACTED TO 95% OF ORIGINAL DENSITY. SOIL SHALL BE TREATED TO PROVIDE 100 KPa LOAD BEARING CAPACITY.
5. INSTALL GENERATOR ANCHOR BOLTS IN ACCORDANCE WITH THE MANUFACTURER'S RECOMMENDATIONS.
6. CHAMFER ALL EXPOSED EDGES.
7. FOR GRADE CROSS-SLOPES, THICKEN THE DOWNHILL END OF THE PAD AS REQUIRED TO MAINTAIN THE EMBEDMENT BELOW GRADE SHOWN IN THE DETAIL.
8. PROVIDE FLEXIBLE CONDUIT FROM THE SLAB PENETRATION TO THE GENERATOR CONNECTION BOX. PROVIDE MINIMUM 150mm SLACK CONDUCTORS AT EACH TERMINATION TO ALLOW FOR MOVEMENT IN CASE OF SEISMIC OR OTHER EVENTS.
9. WHERE CONDUIT BLOCKOUTS ARE PROVIDED IN PAD. LOCATE OPENING PER MANUFACTURER'S RECOMMENDATIONS AND CENTER WITHIN THE WIDTH OF THE PAD. THE OPENING SHALL BE (A) NO WIDER THAN 1/3 OF THE PAD WIDTH, (B) NO LONGER THAN 1/2 THE WIDTH OF THE PAD, AND (C) THE OPENING SHALL BE NO CLOSER TO THE END OF THE PAD THAN 1/3 THE WIDTH OF THE PAD OR 300mm.
10. WHERE CONDUIT BLOCKOUTS ARE PROVIDED IN PAD PROVIDE 13mm X 600mm CORNER BARS AS SHOWN. PROVIDE ADDITIONAL 13mm BARS ON EACH SIDE OF THE OPENING AND TIE TO THE BARS CUT FOR THE OPENING. EXTEND BARS ON EACH SIDE A MINIMUM OF 250mm BEYOND THE OPENING AT EACH END. ALL BARS PROVIDED FOR OPENING SHALL BE A MINIMUM OF 50mm FROM THE EDGE OF THE OPENING.
11. PROVIDE TWO 19mm X 3050mm COPPER CLAD STEEL GROUND RODS 3050MM APART. BOND GROUND RODS TOGETHER UTILIZING MECHANICAL GROUND CONNECTORS AND 35mm² BARE COPPER GROUND CONDUCTORS. ROUTE GROUND CONDUCTOR FROM GROUND ROD THROUGH PAD TO BOND TO GROUND LUG ON GENERATOR CHASSIS.

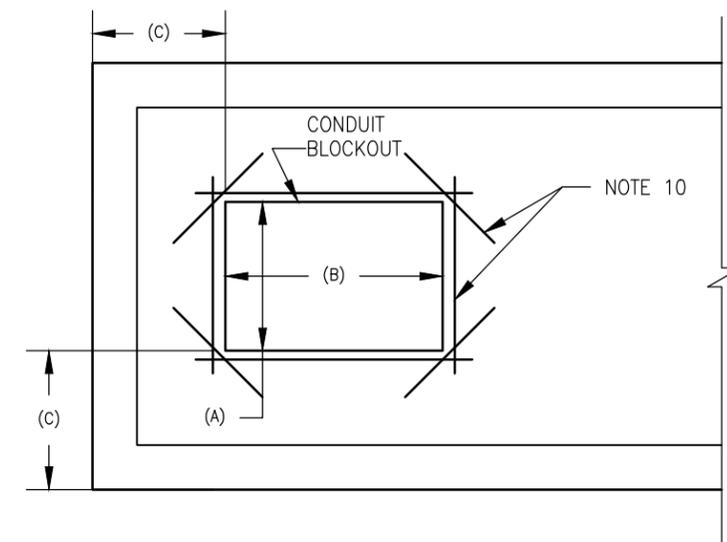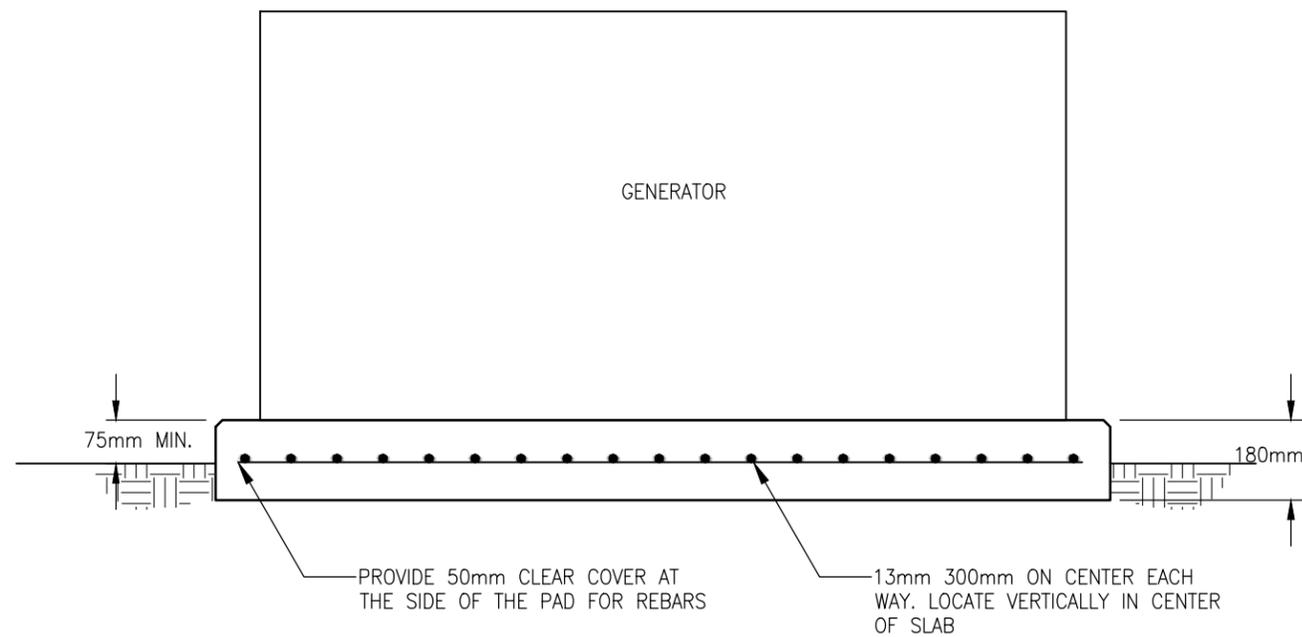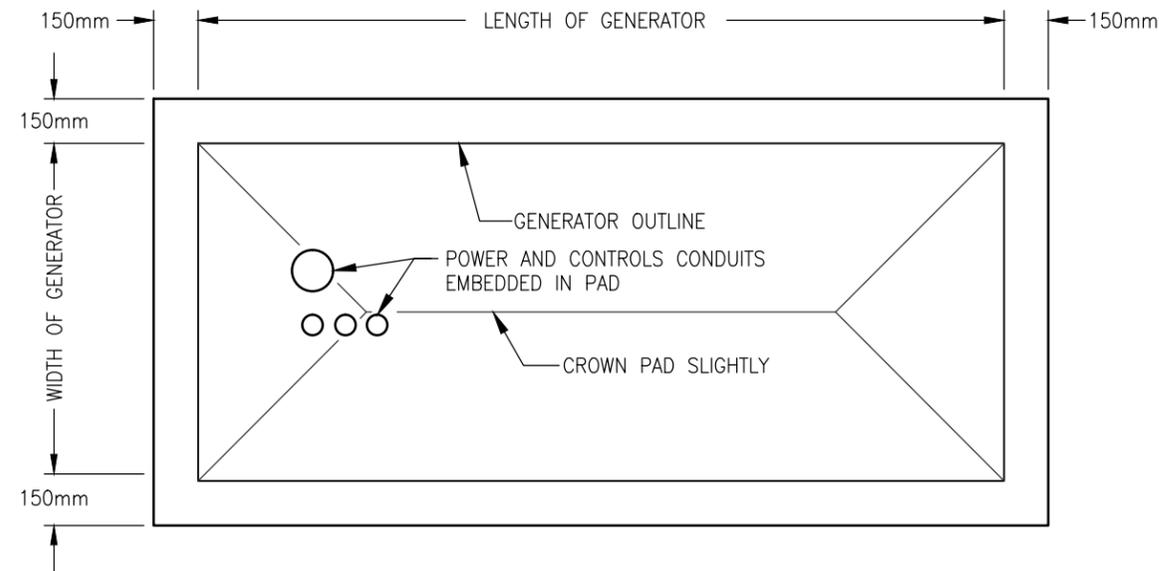

1
G2

34KVA TO 65KVA
GENERATOR PAD DETAIL

SCALE: NTS



United States Department of State
OFFICE OF OVERSEAS BUILDINGS OPERATIONS
Washington, D.C.

STANDARD RESIDENTIAL
GENERATOR
INSTALLATION DETAILS

Drawing Title

STANDARD
GENERATOR PAD
DETAILS - 66KVA
TO 110KVA




Sheet Number

G3

Date:
9/17/13

NOTES

1. ALL CONCRETE SHALL BE NORMAL WEIGHT AND SHALL ATTAIN THE MINIMUM 28-DAY COMPRESSIVE STRENGTHS OF 25MPa AND 0.45 MAXIMUM W/C RATIOS AND CEMENTITIOUS MATERIALS CONTENT.
2. PROVIDE CLEAR DISTANCE TO OUTERMOST REINFORCING AS FOLLOWS:
CONCRETE CAST AGAINST AND EXPOSED TO EARTH - 75mm
CONCRETE EXPOSED TO EARTH OR WEATHER - 50mm
3. REINFORCING STEEL SHALL BE NEW DEFORMED BILLET STEEL CONFORMING TO A615/615M GRADE 420.
4. SOIL TO BE COMPACTED TO 95% OF ORIGINAL DENSITY. SOIL SHALL BE TREATED TO PROVIDE 100 KPa LOAD BEARING CAPACITY.
5. INSTALL GENERATOR ANCHOR BOLTS IN ACCORDANCE WITH THE MANUFACTURER'S RECOMMENDATIONS.
6. CHAMFER ALL EXPOSED EDGES.
7. FOR GRADE CROSS-SLOPES, THICKEN THE DOWNHILL END OF THE PAD AS REQUIRED TO MAINTAIN THE EMBEDMENT BELOW GRADE SHOWN IN THE DETAIL.
8. PROVIDE FLEXIBLE CONDUIT FROM THE SLAB PENETRATION TO THE GENERATOR CONNECTION BOX. PROVIDE MINIMUM 150mm SLACK CONDUCTORS AT EACH TERMINATION TO ALLOW FOR MOVEMENT IN CASE OF SEISMIC OR OTHER EVENTS.
9. WHERE CONDUIT BLOCKOUTS ARE PROVIDED IN PAD. LOCATE OPENING PER MANUFACTURER'S RECOMMENDATIONS AND CENTER WITHIN THE WIDTH OF THE PAD. THE OPENING SHALL BE (A) NO WIDER THAN 1/3 OF THE PAD WIDTH, (B) NO LONGER THAN 1/2 THE WIDTH OF THE PAD, AND (C) THE OPENING SHALL BE NO CLOSER TO THE END OF THE PAD THAN 1/3 THE WIDTH OF THE PAD OR 300mm.
10. WHERE CONDUIT BLOCKOUTS ARE PROVIDED IN PAD PROVIDE 13mm X 600mm CORNER BARS AS SHOWN. PROVIDE ADDITIONAL 13mm BARS ON EACH SIDE OF THE OPENING AND TIE TO THE BARS CUT FOR THE OPENING. EXTEND BARS ON EACH SIDE A MINIMUM OF 250mm BEYOND THE OPENING AT EACH END. ALL BARS PROVIDED FOR OPENING SHALL BE A MINIMUM OF 50mm FROM THE EDGE OF THE OPENING.
11. PROVIDE TWO 19mm X 3050mm COPPER CLAD STEEL GROUND RODS 3050MM APART. BOND GROUND RODS TOGETHER UTILIZING MECHANICAL GROUND CONNECTORS AND 35mm² BARE COPPER GROUND CONDUCTORS. ROUTE GROUND CONDUCTOR FROM GROUND ROD THROUGH PAD TO BOND TO GROUND LUG ON GENERATOR CHASSIS.

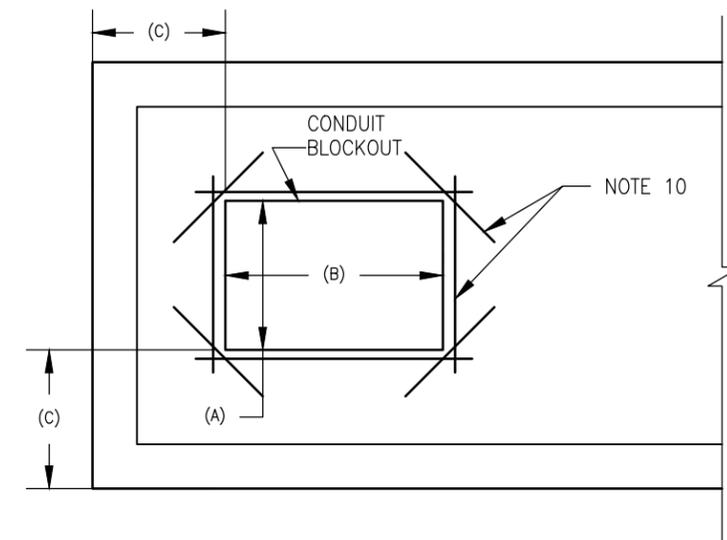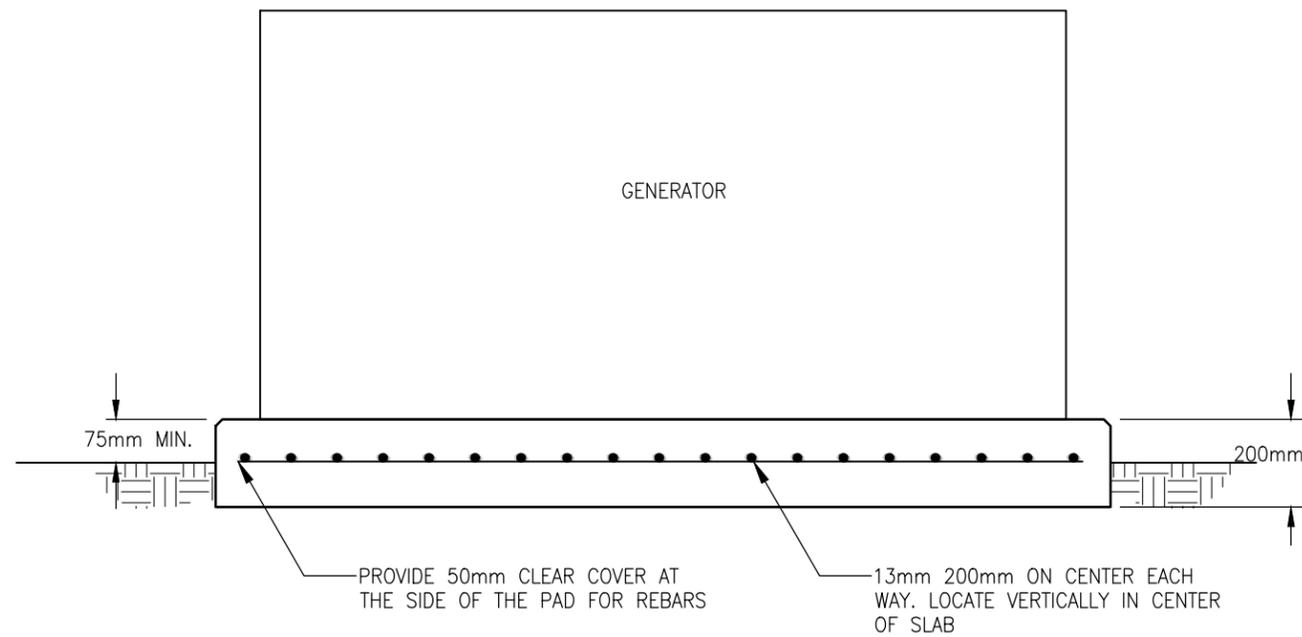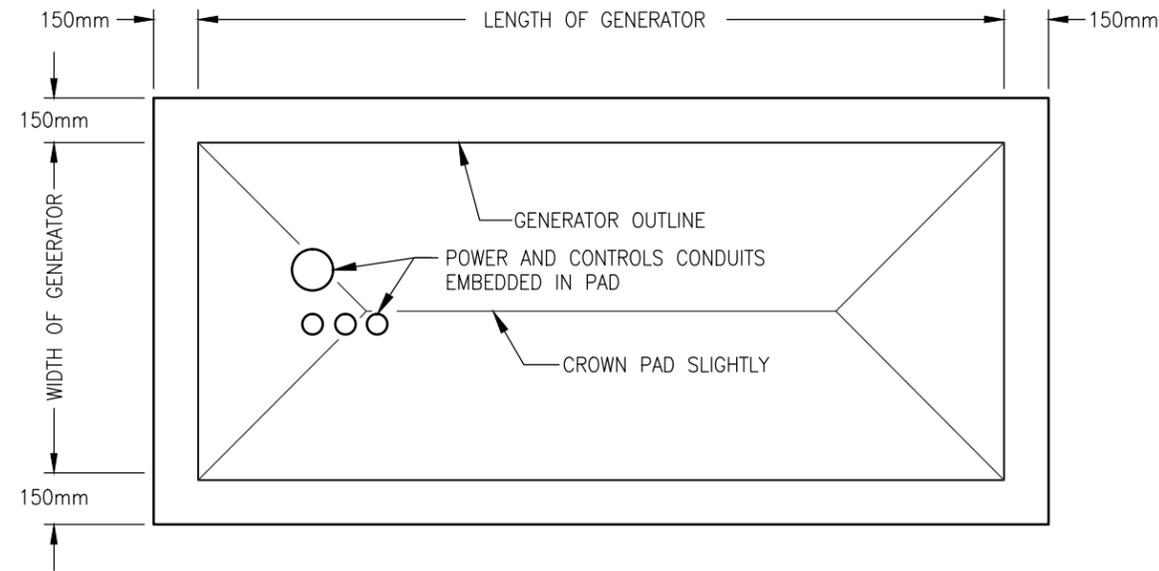

1
G3
66KVA TO 110KVA
GENERATOR PAD DETAIL
SCALE: NTS



United States Department of State
OFFICE OF OVERSEAS BUILDINGS OPERATIONS
Washington, D.C.

STANDARD RESIDENTIAL
GENERATOR
INSTALLATION DETAILS

Drawing Title

STANDARD
GENERATOR PAD
DETAILS - 111KVA
TO 200KVA



Sheet Number

G4

Date:
9/17/13

NOTES

1. ALL CONCRETE SHALL BE NORMAL WEIGHT AND SHALL ATTAIN THE MINIMUM 28-DAY COMPRESSIVE STRENGTHS OF 25MPa AND 0.45 MAXIMUM W/C RATIOS AND CEMENTITIOUS MATERIALS CONTENT.
2. PROVIDE CLEAR DISTANCE TO OUTERMOST REINFORCING AS FOLLOWS:
CONCRETE CAST AGAINST AND EXPOSED TO EARTH - 75mm
CONCRETE EXPOSED TO EARTH OR WEATHER - 50mm
3. REINFORCING STEEL SHALL BE NEW DEFORMED BILLET STEEL CONFORMING TO A615/615M GRADE 420.
4. SOIL TO BE COMPACTED TO 95% OF ORIGINAL DENSITY. SOIL SHALL BE TREATED TO PROVIDE 100 KPa LOAD BEARING CAPACITY.
5. INSTALL GENERATOR ANCHOR BOLTS IN ACCORDANCE WITH THE MANUFACTURER'S RECOMMENDATIONS.
6. CHAMFER ALL EXPOSED EDGES.
7. FOR GRADE CROSS-SLOPES, THICKEN THE DOWNHILL END OF THE PAD AS REQUIRED TO MAINTAIN THE EMBEDMENT BELOW GRADE SHOWN IN THE DETAIL.
8. PROVIDE FLEXIBLE CONDUIT FROM THE SLAB PENETRATION TO THE GENERATOR CONNECTION BOX. PROVIDE MINIMUM 150mm SLACK CONDUCTORS AT EACH TERMINATION TO ALLOW FOR MOVEMENT IN CASE OF SEISMIC OR OTHER EVENTS.
9. WHERE CONDUIT BLOCKOUTS ARE PROVIDED IN PAD. LOCATE OPENING PER MANUFACTURER'S RECOMMENDATIONS AND CENTER WITHIN THE WIDTH OF THE PAD. THE OPENING SHALL BE (A) NO WIDER THAN 1/3 OF THE PAD WIDTH, (B) NO LONGER THAN 1/2 THE WIDTH OF THE PAD, AND (C) THE OPENING SHALL BE NO CLOSER TO THE END OF THE PAD THAN 1/3 THE WIDTH OF THE PAD OR 300mm.
10. WHERE CONDUIT BLOCKOUTS ARE PROVIDED IN PAD PROVIDE 13mm X 600mm CORNER BARS AS SHOWN. PROVIDE ADDITIONAL 13mm BARS ON EACH SIDE OF THE OPENING AND TIE TO THE BARS CUT FOR THE OPENING. EXTEND BARS ON EACH SIDE A MINIMUM OF 250mm BEYOND THE OPENING AT EACH END. ALL BARS PROVIDED FOR OPENING SHALL BE A MINIMUM OF 50mm FROM THE EDGE OF THE OPENING.
11. GROUND GENERATOR PER LARGE GENERATOR GROUNDING DETAIL ON SHEET G8.

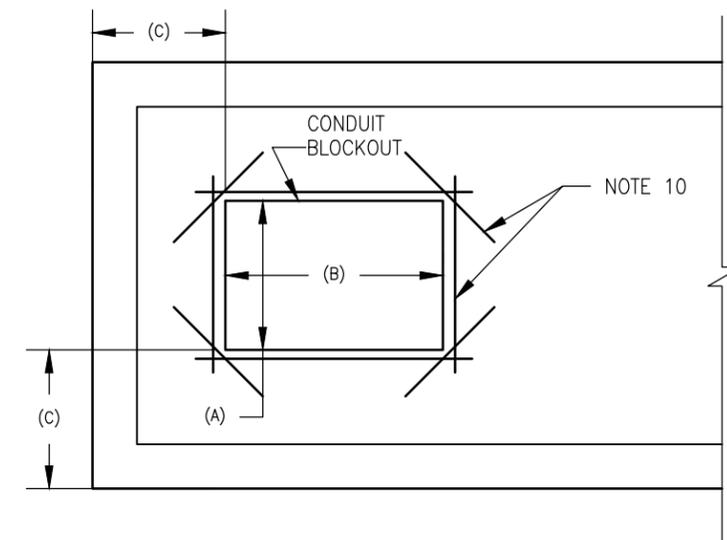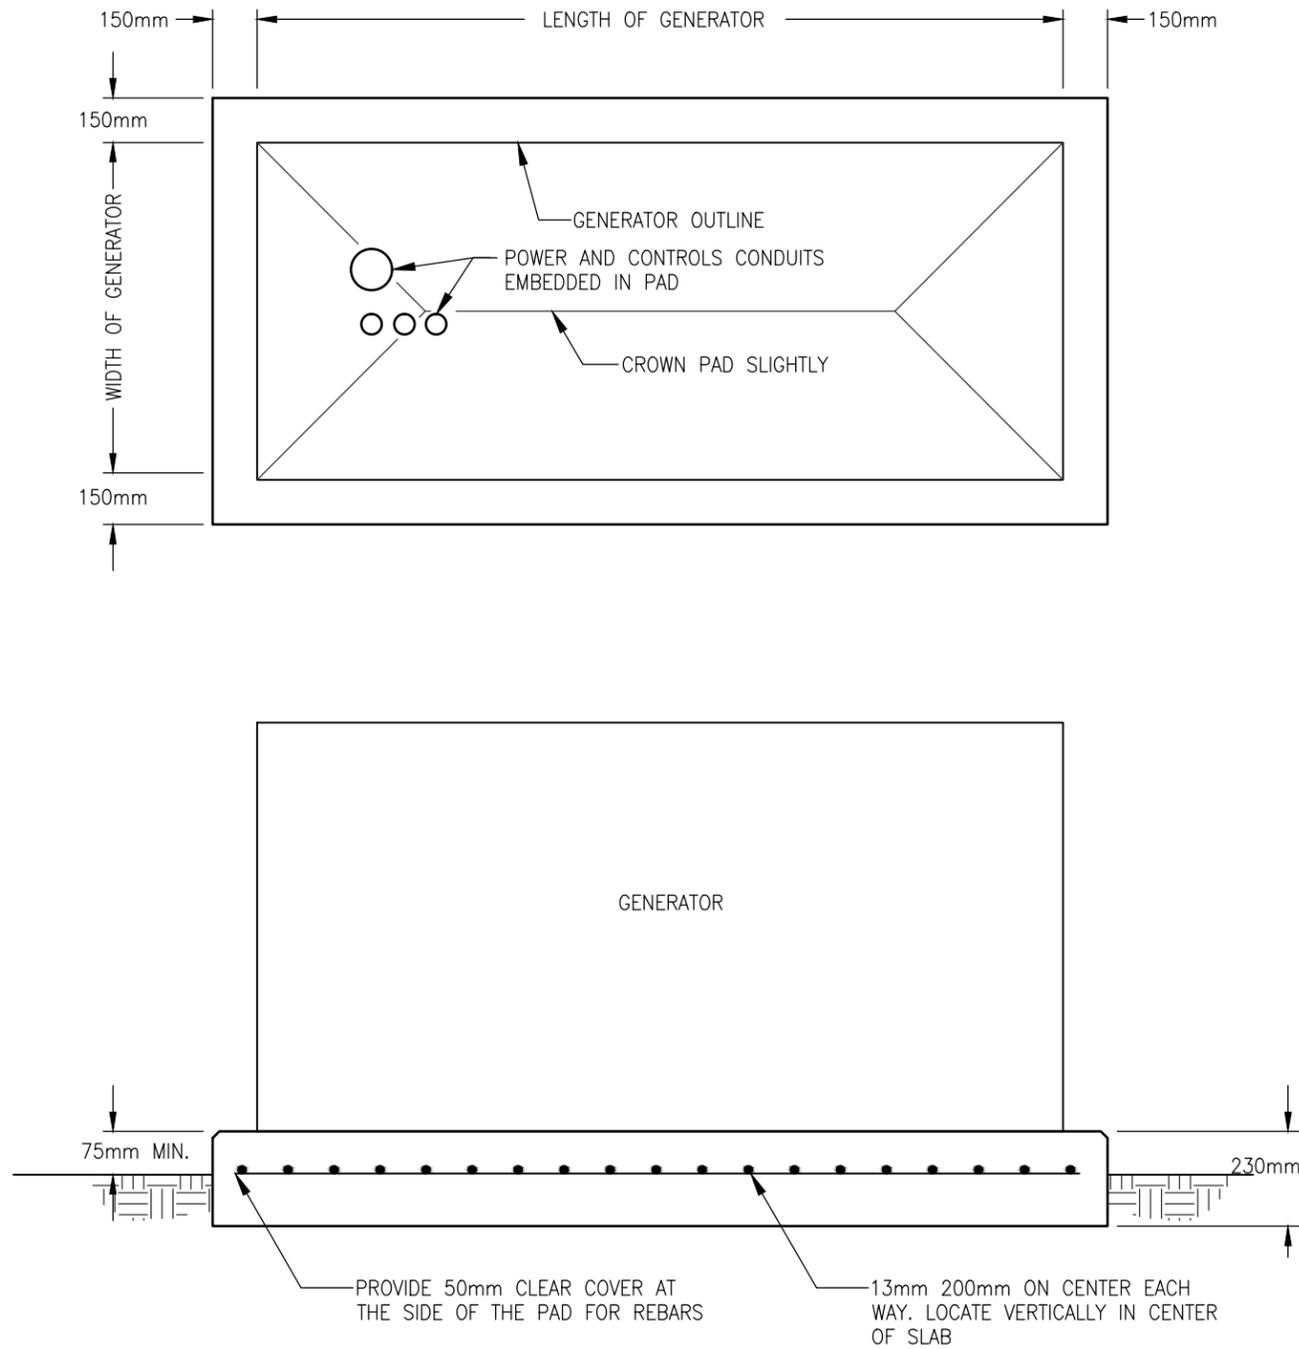

1
G4

111KVA TO 200KVA
GENERATOR PAD DETAIL

SCALE: NTS



United States Department of State
OFFICE OF OVERSEAS BUILDINGS OPERATIONS
Washington, D.C.

STANDARD RESIDENTIAL
GENERATOR
INSTALLATION DETAILS

Drawing Title

STANDARD
GENERATOR PAD
DETAILS - 201KVA
TO 275KVA




Sheet Number

G5

Date:
9/17/13

NOTES

1. ALL CONCRETE SHALL BE NORMAL WEIGHT AND SHALL ATTAIN THE MINIMUM 28-DAY COMPRESSIVE STRENGTHS OF 25MPa AND 0.45 MAXIMUM W/C RATIOS AND CEMENTITIOUS MATERIALS CONTENT.
2. PROVIDE CLEAR DISTANCE TO OUTERMOST REINFORCING AS FOLLOWS:
CONCRETE CAST AGAINST AND EXPOSED TO EARTH - 75mm
CONCRETE EXPOSED TO EARTH OR WEATHER - 50mm
3. REINFORCING STEEL SHALL BE NEW DEFORMED BILLET STEEL CONFORMING TO A615/615M GRADE 420.
4. SOIL TO BE COMPACTED TO 95% OF ORIGINAL DENSITY. SOIL SHALL BE TREATED TO PROVIDE 100 KPa LOAD BEARING CAPACITY.
5. INSTALL GENERATOR ANCHOR BOLTS IN ACCORDANCE WITH THE MANUFACTURER'S RECOMMENDATIONS.
6. CHAMFER ALL EXPOSED EDGES.
7. FOR GRADE CROSS-SLOPES, THICKEN THE DOWNHILL END OF THE PAD AS REQUIRED TO MAINTAIN THE EMBEDMENT BELOW GRADE SHOWN IN THE DETAIL.
8. PROVIDE FLEXIBLE CONDUIT FROM THE SLAB PENETRATION TO THE GENERATOR CONNECTION BOX. PROVIDE MINIMUM 150mm SLACK CONDUCTORS AT EACH TERMINATION TO ALLOW FOR MOVEMENT IN CASE OF SEISMIC OR OTHER EVENTS.
9. WHERE CONDUIT BLOCKOUTS ARE PROVIDED IN PAD. LOCATE OPENING PER MANUFACTURER'S RECOMMENDATIONS AND CENTER WITHIN THE WIDTH OF THE PAD. THE OPENING SHALL BE (A) NO WIDER THAN 1/3 OF THE PAD WIDTH, (B) NO LONGER THAN 1/2 THE WIDTH OF THE PAD, AND (C) THE OPENING SHALL BE NO CLOSER TO THE END OF THE PAD THAN 1/3 THE WIDTH OF THE PAD OR 300mm.
10. WHERE CONDUIT BLOCKOUTS ARE PROVIDED IN PAD PROVIDE 13mm X 600mm CORNER BARS FOR BOTH TOP AND BOTTOM LAYERS AS SHOWN. PROVIDE ADDITIONAL 13mm BARS ON EACH SIDE OF THE OPENING AND TIE TO THE BARS CUT FOR THE OPENING FOR EACH LAYER OF REINFORCING STEEL. EXTEND BARS ON EACH SIDE A MINIMUM OF 250mm BEYOND THE OPENING AT EACH END. ALL BARS PROVIDED FOR OPENING SHALL BE A MINIMUM OF 50mm FROM THE EDGE OF THE OPENING.
11. GROUND GENERATOR PER LARGE GENERATOR GROUNDING DETAIL ON SHEET G8.

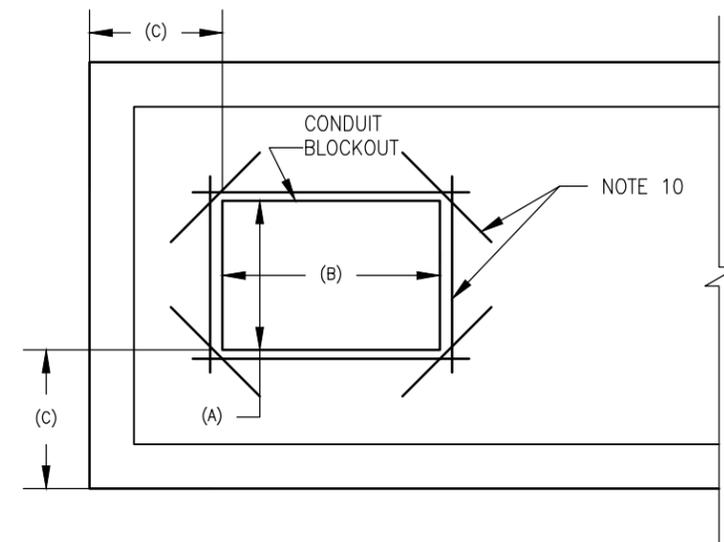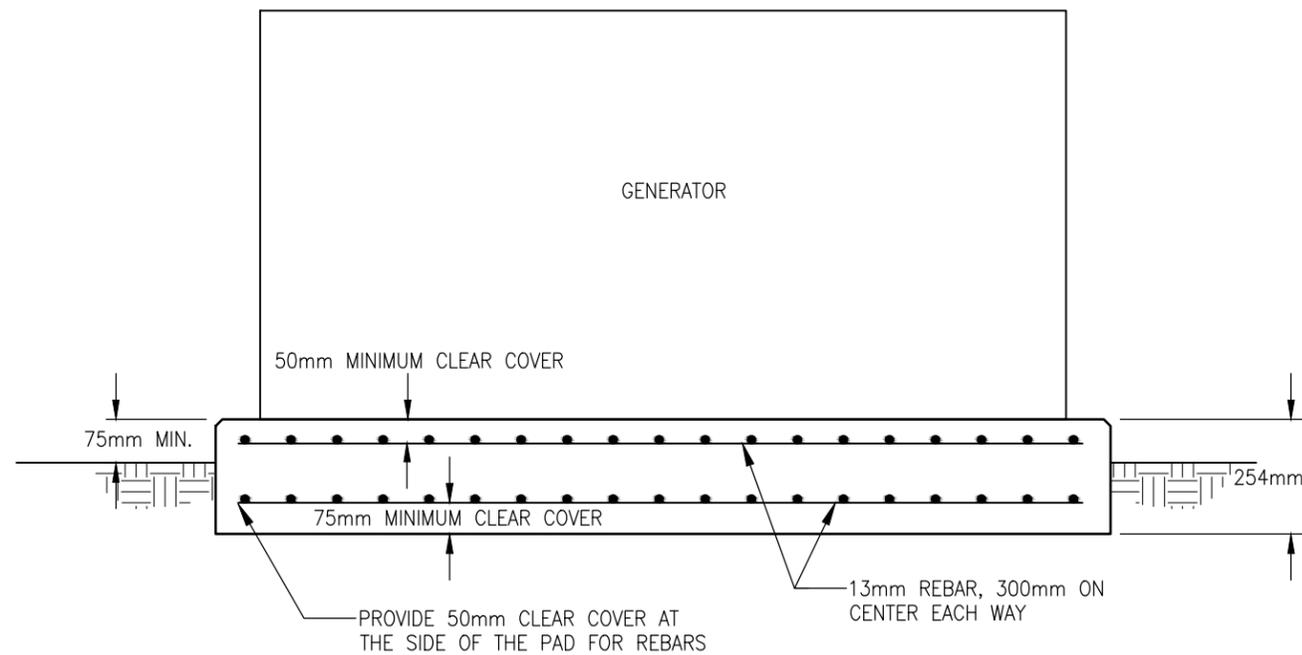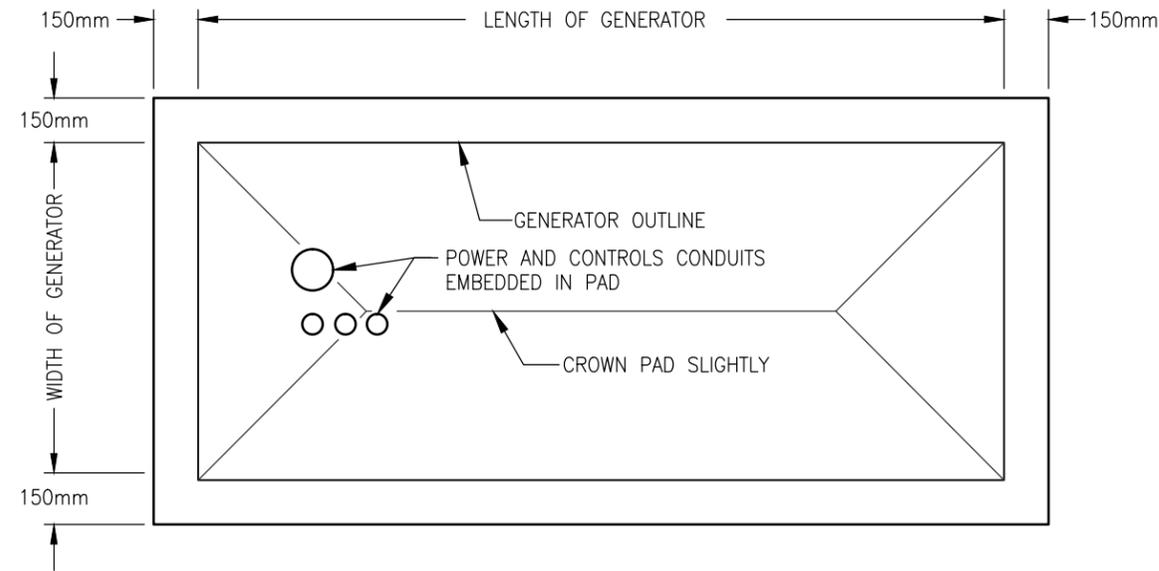

1
G5

**201KVA TO 275KVA
GENERATOR PAD DETAIL**

SCALE: NTS



United States Department of State
OFFICE OF OVERSEAS BUILDINGS OPERATIONS
Washington, D.C.

STANDARD RESIDENTIAL
GENERATOR
INSTALLATION DETAILS

Drawing Title

STANDARD
GENERATOR PAD
DETAILS - 276KVA
TO 450KVA




Sheet Number

G6

Date:
9/17/13

NOTES

1. ALL CONCRETE SHALL BE NORMAL WEIGHT AND SHALL ATTAIN THE MINIMUM 28-DAY COMPRESSIVE STRENGTHS OF 25MPa AND 0.45 MAXIMUM W/C RATIOS AND CEMENTITIOUS MATERIALS CONTENT.
2. PROVIDE CLEAR DISTANCE TO OUTERMOST REINFORCING AS FOLLOWS:
CONCRETE CAST AGAINST AND EXPOSED TO EARTH - 75mm
CONCRETE EXPOSED TO EARTH OR WEATHER - 50mm
3. REINFORCING STEEL SHALL BE NEW DEFORMED BILLET STEEL CONFORMING TO A615/615M GRADE 420.
4. SOIL TO BE COMPACTED TO 95% OF ORIGINAL DENSITY. SOIL SHALL BE TREATED TO PROVIDE 100 KPa LOAD BEARING CAPACITY.
5. INSTALL GENERATOR ANCHOR BOLTS IN ACCORDANCE WITH THE MANUFACTURER'S RECOMMENDATIONS.
6. CHAMFER ALL EXPOSED EDGES.
7. FOR GRADE CROSS-SLOPES, THICKEN THE DOWNHILL END OF THE PAD AS REQUIRED TO MAINTAIN THE EMBEDMENT BELOW GRADE SHOWN IN THE DETAIL.
8. PROVIDE FLEXIBLE CONDUIT FROM THE SLAB PENETRATION TO THE GENERATOR CONNECTION BOX. PROVIDE MINIMUM 150mm SLACK CONDUCTORS AT EACH TERMINATION TO ALLOW FOR MOVEMENT IN CASE OF SEISMIC OR OTHER EVENTS.
9. WHERE CONDUIT BLOCKOUTS ARE PROVIDED IN PAD. LOCATE OPENING PER MANUFACTURER'S RECOMMENDATIONS AND CENTER WITHIN THE WIDTH OF THE PAD. THE OPENING SHALL BE (A) NO WIDER THAN 1/3 OF THE PAD WIDTH, (B) NO LONGER THAN 1/2 THE WIDTH OF THE PAD, AND (C) THE OPENING SHALL BE NO CLOSER TO THE END OF THE PAD THAN 1/3 THE WIDTH OF THE PAD OR 300mm.
10. WHERE CONDUIT BLOCKOUTS ARE PROVIDED IN PAD PROVIDE 13mm X 600mm CORNER BARS FOR BOTH TOP AND BOTTOM LAYERS AS SHOWN. PROVIDE ADDITIONAL 13mm BARS ON EACH SIDE OF THE OPENING AND TIE TO THE BARS CUT FOR THE OPENING FOR EACH LAYER OF REINFORCING STEEL. EXTEND BARS ON EACH SIDE A MINIMUM OF 250mm BEYOND THE OPENING AT EACH END. ALL BARS PROVIDED FOR OPENING SHALL BE A MINIMUM OF 50mm FROM THE EDGE OF THE OPENING.
11. GROUND GENERATOR PER LARGE GENERATOR GROUNDING DETAIL ON SHEET G8.

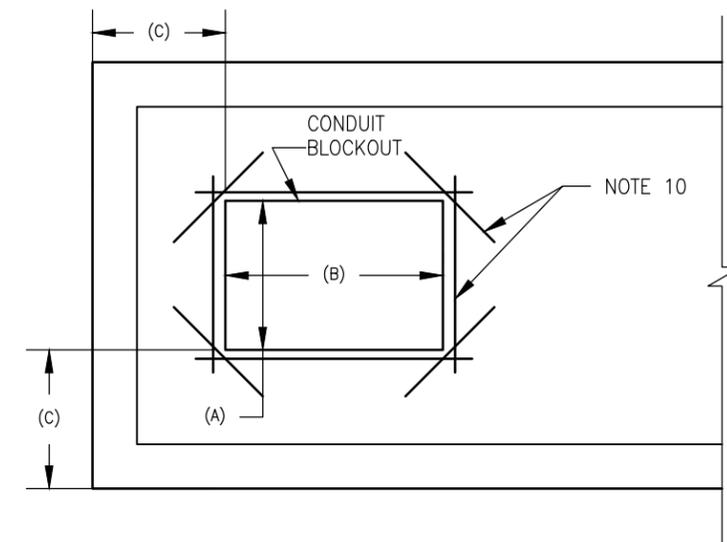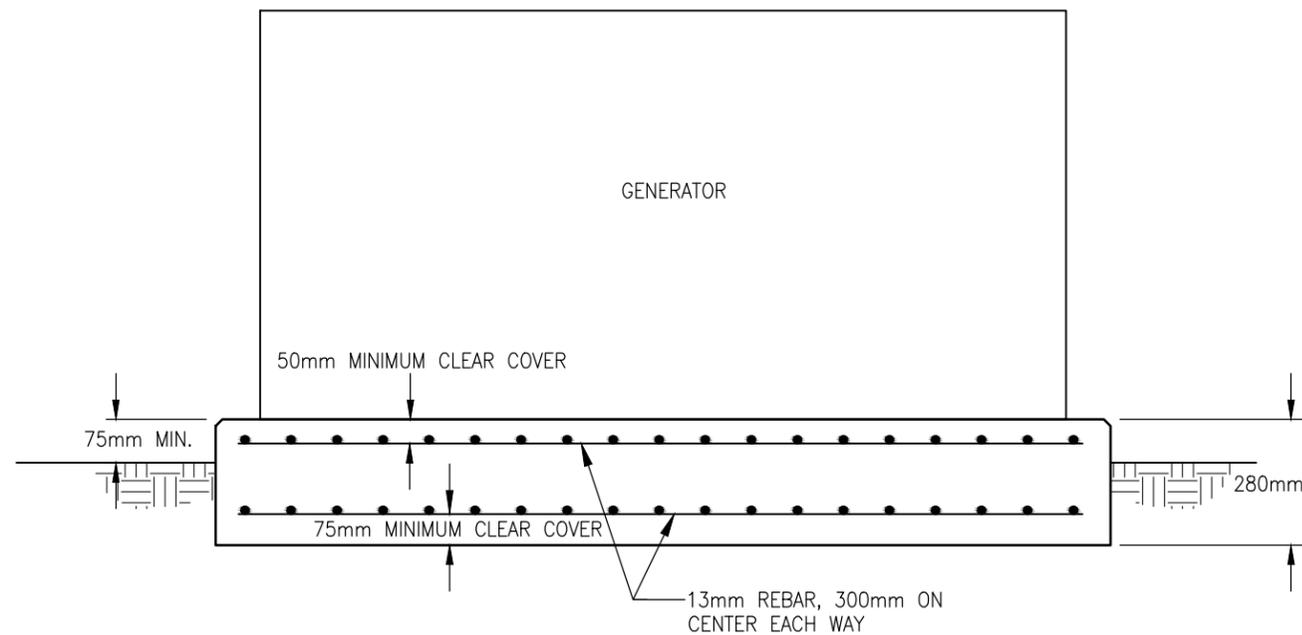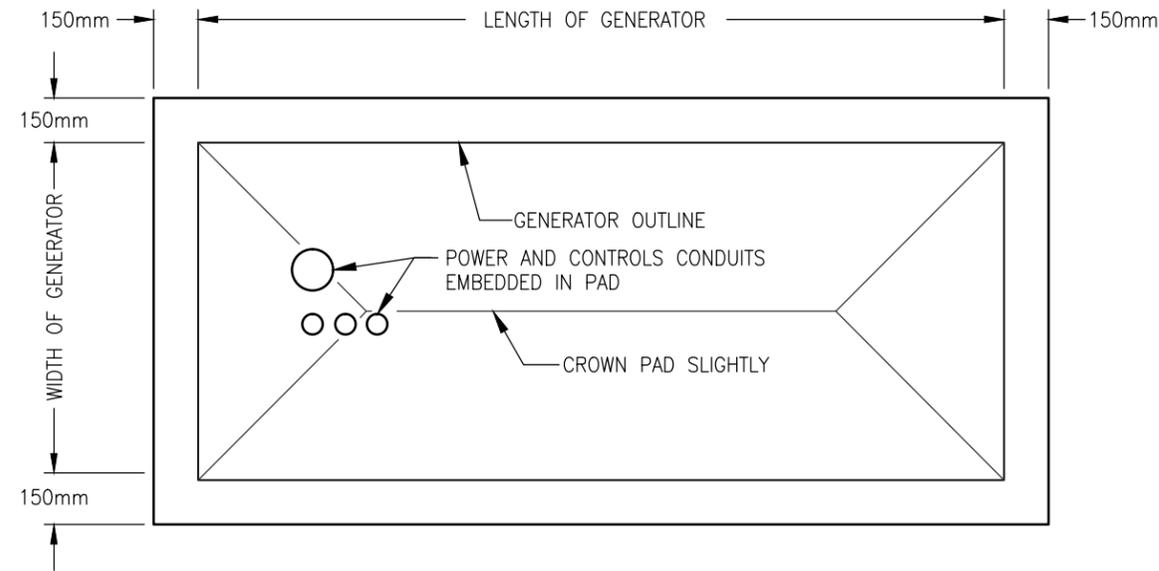

1
G6

276KVA TO 450KVA
GENERATOR PAD DETAIL

SCALE: NTS



United States Department of State
OFFICE OF OVERSEAS BUILDINGS OPERATIONS
Washington, D.C.

STANDARD RESIDENTIAL
GENERATOR
INSTALLATION DETAILS

Drawing Title
**STANDARD
GENERATOR PAD
DETAILS - 500KVA**




Sheet Number

G7

Date:
9/17/13

NOTES


1. ALL CONCRETE SHALL BE NORMAL WEIGHT AND SHALL ATTAIN THE MINIMUM 28-DAY COMPRESSIVE STRENGTHS OF 25MPa AND 0.45 MAXIMUM W/C RATIOS AND CEMENTITIOUS MATERIALS CONTENT.
2. PROVIDE CLEAR DISTANCE TO OUTERMOST REINFORCING AS FOLLOWS:
CONCRETE CAST AGAINST AND EXPOSED TO EARTH - 75mm
CONCRETE EXPOSED TO EARTH OR WEATHER - 50mm
3. REINFORCING STEEL SHALL BE NEW DEFORMED BILLET STEEL CONFORMING TO A615/615M GRADE 420.
4. SOIL TO BE COMPACTED TO 95% OF ORIGINAL DENSITY. SOIL SHALL BE TREATED TO PROVIDE 100 KPa LOAD BEARING CAPACITY.
5. INSTALL GENERATOR ANCHOR BOLTS IN ACCORDANCE WITH THE MANUFACTURER'S RECOMMENDATIONS.
6. CHAMFER ALL EXPOSED EDGES.
7. FOR GRADE CROSS-SLOPES, THICKEN THE DOWNHILL END OF THE PAD AS REQUIRED TO MAINTAIN THE EMBEDMENT BELOW GRADE SHOWN IN THE DETAIL.
8. PROVIDE FLEXIBLE CONDUIT FROM THE SLAB PENETRATION TO THE GENERATOR CONNECTION BOX. PROVIDE MINIMUM 150mm SLACK CONDUCTORS AT EACH TERMINATION TO ALLOW FOR MOVEMENT IN CASE OF SEISMIC OR OTHER EVENTS.
9. WHERE CONDUIT BLOCKOUTS ARE PROVIDED IN PAD. LOCATE OPENING PER MANUFACTURER'S RECOMMENDATIONS AND CENTER WITHIN THE WIDTH OF THE PAD. THE OPENING SHALL BE (A) NO WIDER THAN 1/3 OF THE PAD WIDTH, (B) NO LONGER THAN 1/2 THE WIDTH OF THE PAD, AND (C) THE OPENING SHALL BE NO CLOSER TO THE END OF THE PAD THAN 1/3 THE WIDTH OF THE PAD OR 300mm.
10. WHERE CONDUIT BLOCKOUTS ARE PROVIDED IN PAD PROVIDE 13mm X 600mm CORNER BARS FOR BOTH TOP AND BOTTOM LAYERS AS SHOWN. PROVIDE ADDITIONAL 13mm BARS ON EACH SIDE OF THE OPENING AND TIE TO THE BARS CUT FOR THE OPENING FOR EACH LAYER OF REINFORCING STEEL. EXTEND BARS ON EACH SIDE A MINIMUM OF 250mm BEYOND THE OPENING AT EACH END. ALL BARS PROVIDED FOR OPENING SHALL BE A MINIMUM OF 50mm FROM THE EDGE OF THE OPENING.
11. GROUND GENERATOR PER LARGE GENERATOR GROUNDING DETAIL ON SHEET G8.

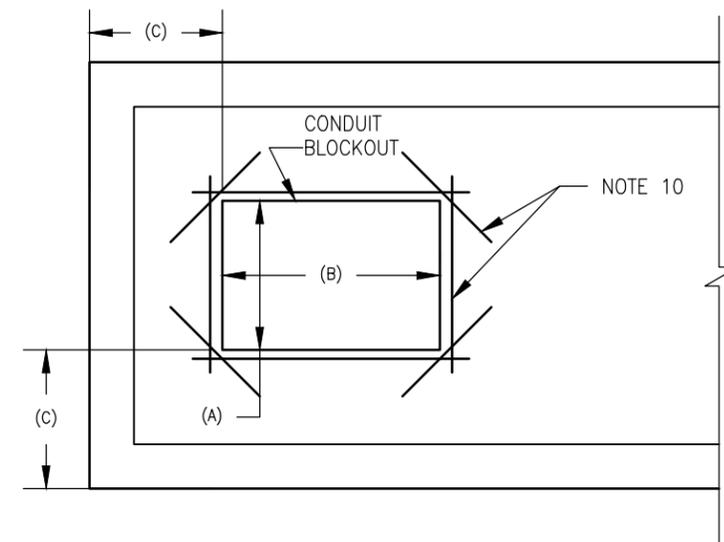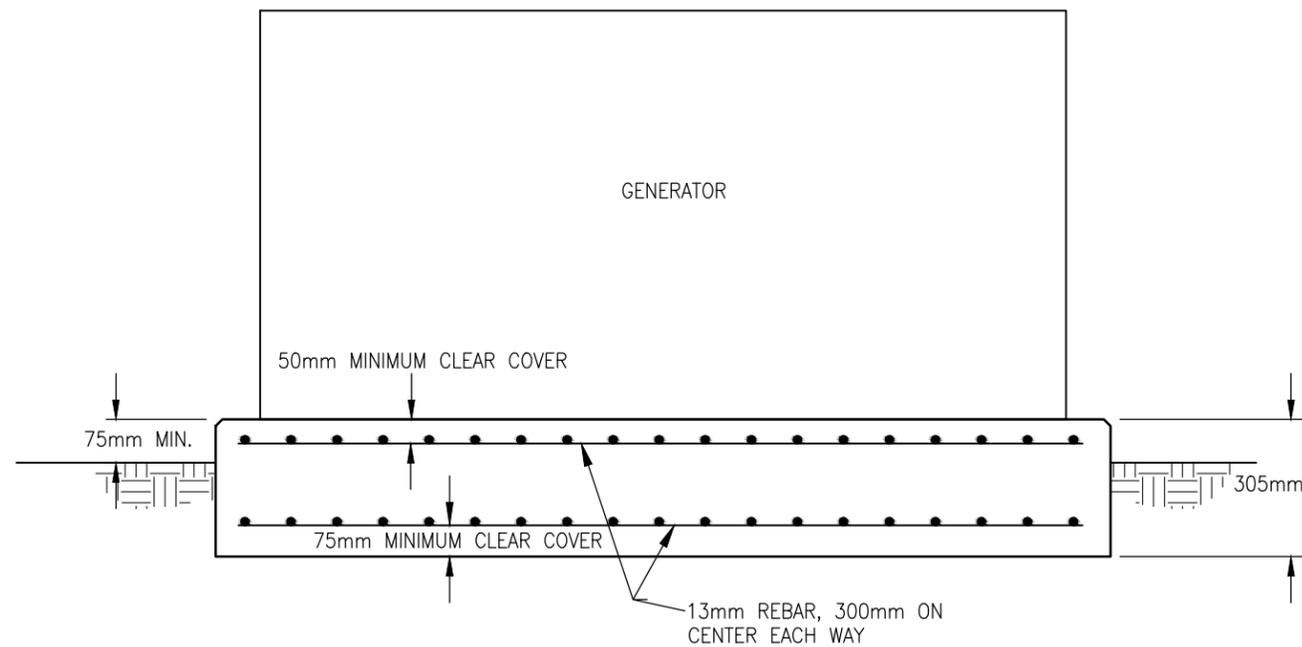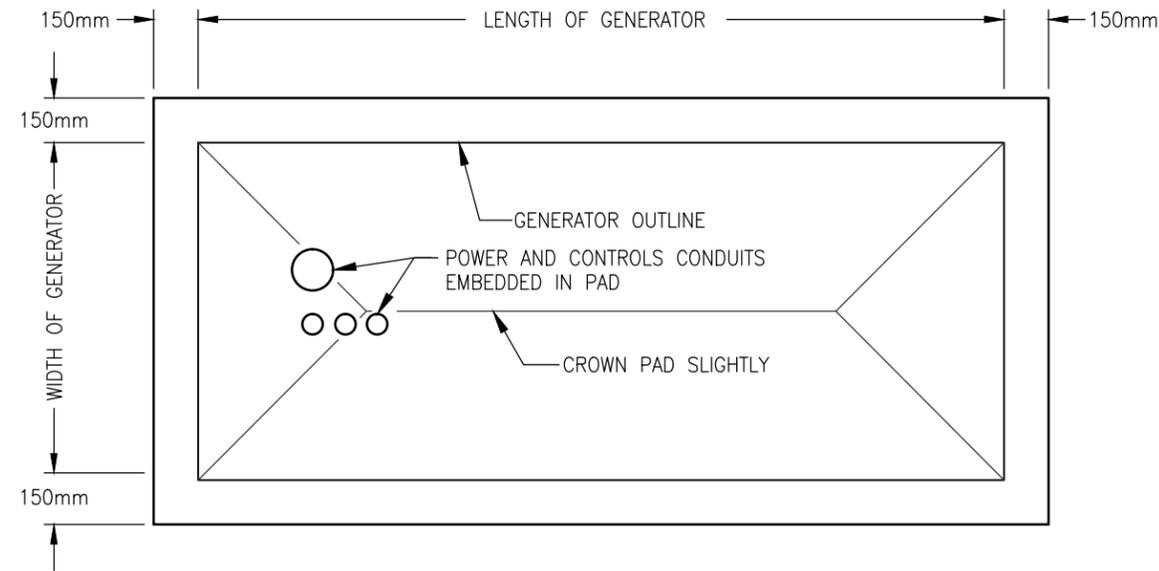

1
G7
**500KVA
GENERATOR PAD DETAIL**
 SCALE: NTS



United States Department of State
OFFICE OF OVERSEAS BUILDINGS OPERATIONS
Washington, D.C.

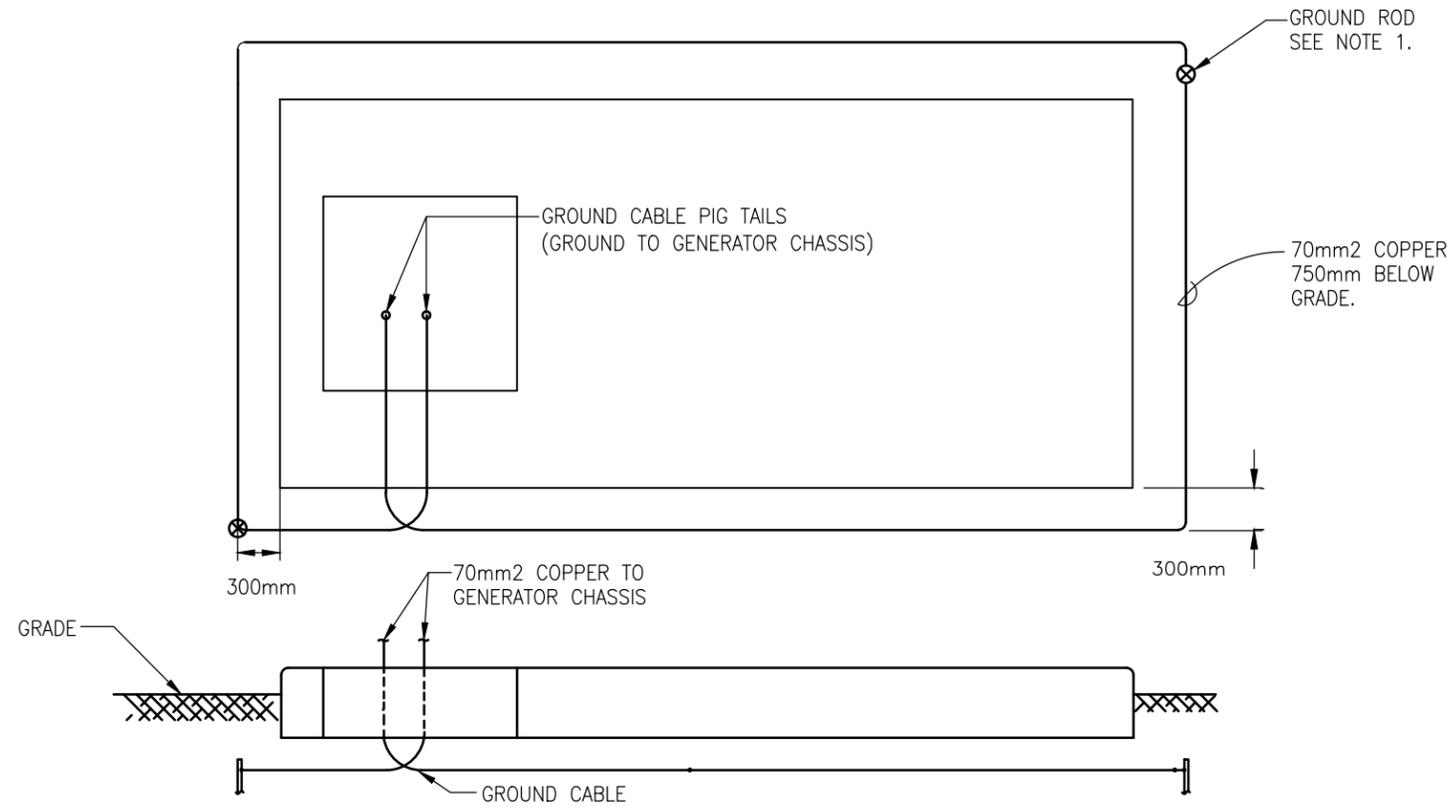

NOTES

1. GROUND ROD - 19mm X 3050mm COPPER CLAD STEEL GROUND ROD.

1
G8

LARGE MULTI-RESIDENCE GENERATOR GROUNDING DETAIL

SCALE: NTS

STANDARD RESIDENTIAL GENERATOR INSTALLATION DETAILS

Drawing Title

LARGE
MULTI-RESIDENCE
GENERATOR
GROUNDING DETAIL

Sheet Number


G8

Date:
9/17/13



United States Department of State
OFFICE OF OVERSEAS BUILDINGS OPERATIONS
Washington, D.C.

STANDARD RESIDENTIAL
GENERATOR
INSTALLATION DETAILS

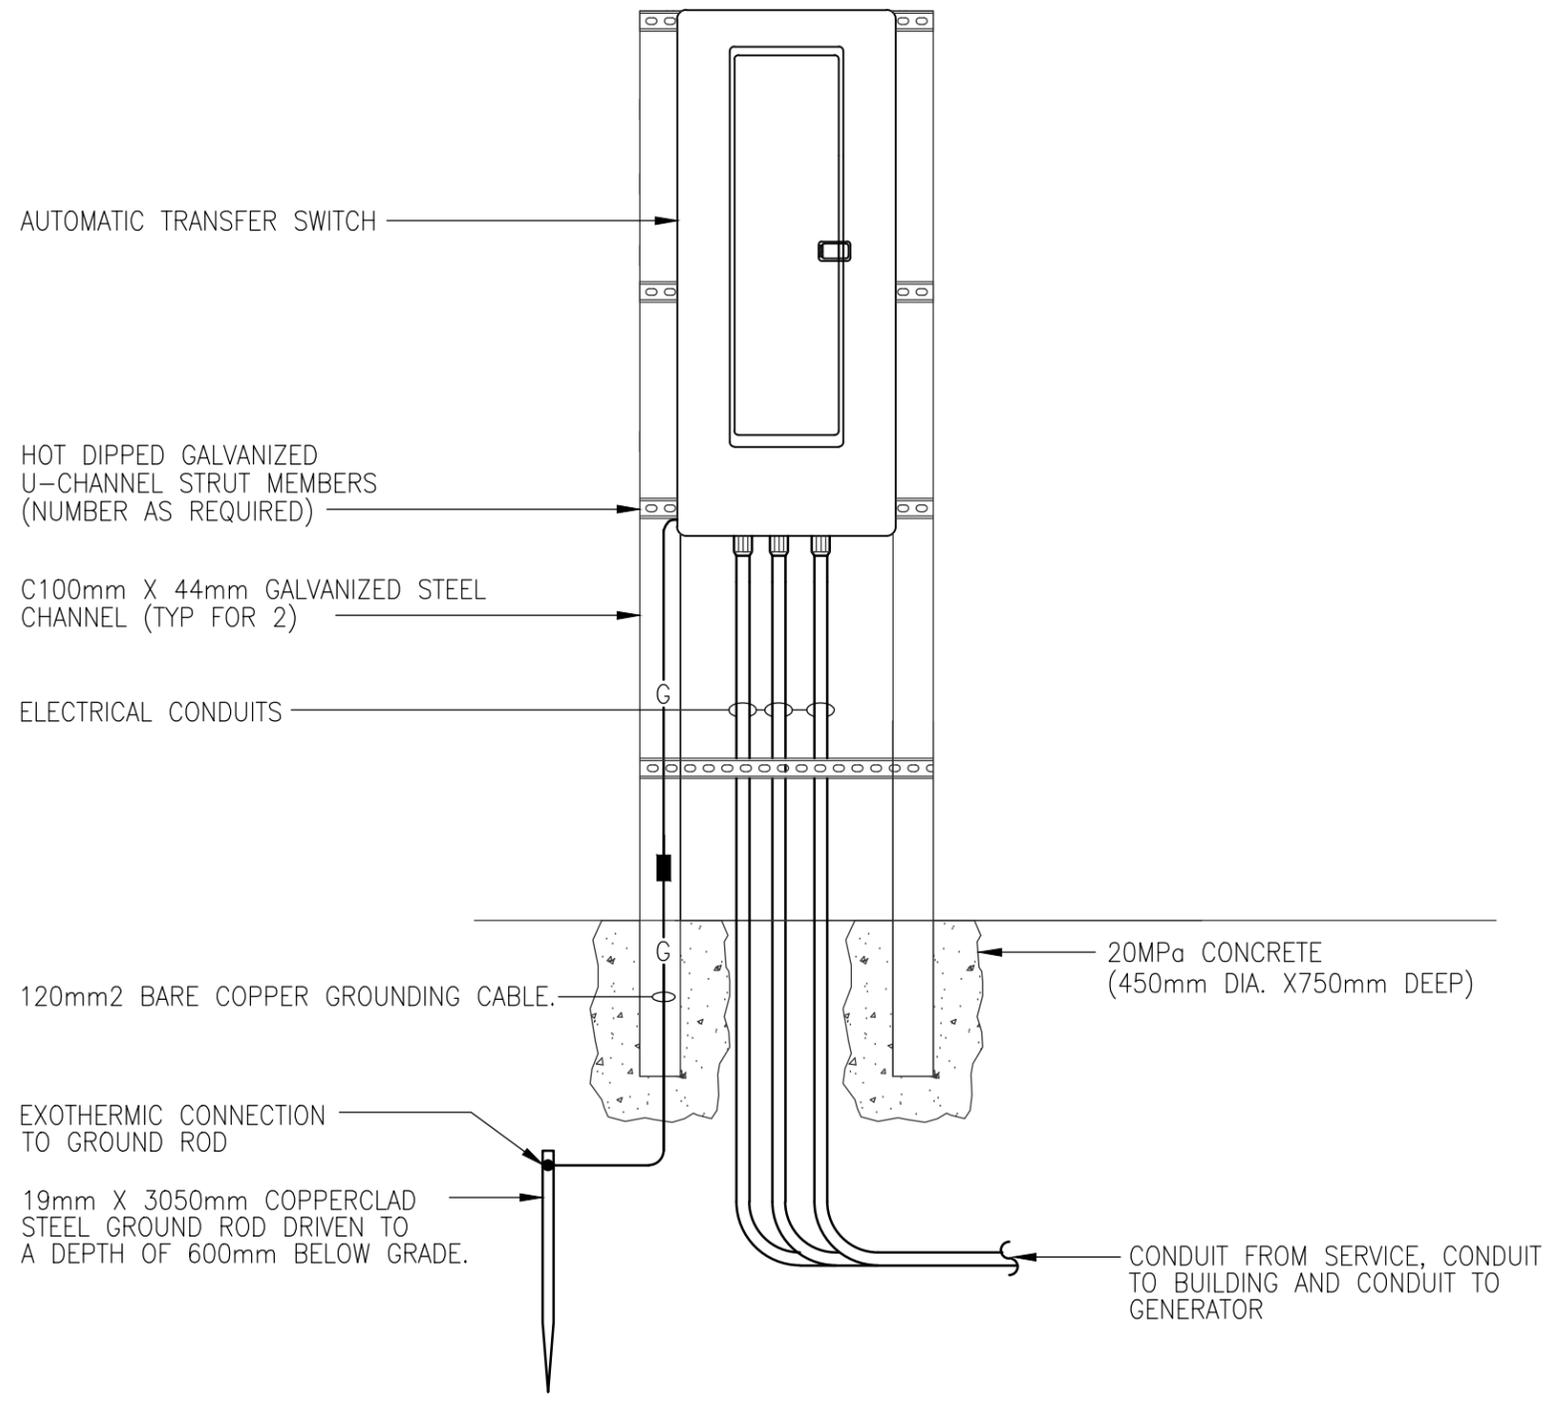

1
G9
**FREESTANDING
ATS SUPPORT DETAIL**
SCALE: NOT TO SCALE


Drawing Title
**FREESTANDING
ATS SUPPORT
DETAIL**

Sheet Number
G9
Date:
9/17/13



United States Department of State
OFFICE OF OVERSEAS BUILDINGS OPERATIONS
Washington, D.C.

STANDARD RESIDENTIAL
GENERATOR
INSTALLATION DETAILS

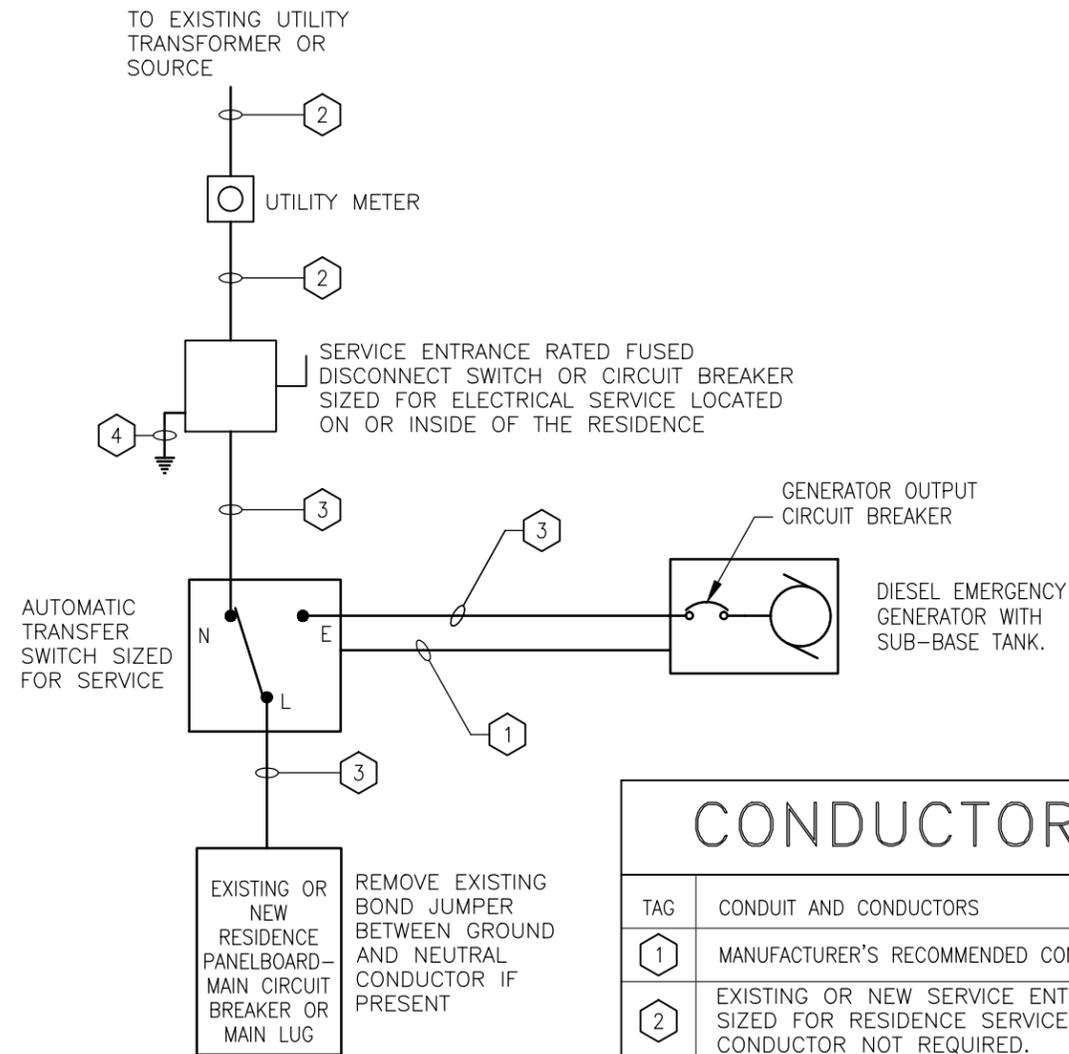

CONDUCTOR SCHEDULE	
TAG	CONDUIT AND CONDUCTORS
1	MANUFACTURER'S RECOMMENDED CONDUIT AND CONTROL CONDUCTORS
2	EXISTING OR NEW SERVICE ENTRANCE CONDUIT AND CONDUCTORS SIZED FOR RESIDENCE SERVICE DISCONNECT AMPS. GROUND CONDUCTOR NOT REQUIRED.
3	CONDUIT AND CONDUCTORS SIZED FOR RESIDENCE SERVICE DISCONNECT AMPS. PROVIDE WITH GROUND CONDUCTOR.
4	PROVIDE GROUND CONDUCTOR AND GROUNDING ELECTRODES PER NOTES ON SHEET G12.

1 ELECTRICAL ONE-LINE DIAGRAM
G10 SCALE: NO SCALE

Drawing Title

TYPICAL
ELECTRICAL
ONE-LINE
DIAGRAM-SINGLE
RESIDENCE

Sheet Number


G10

Date:
9/17/13



United States Department of State
OFFICE OF OVERSEAS BUILDINGS OPERATIONS
Washington, D.C.

STANDARD RESIDENTIAL
GENERATOR
INSTALLATION DETAILS

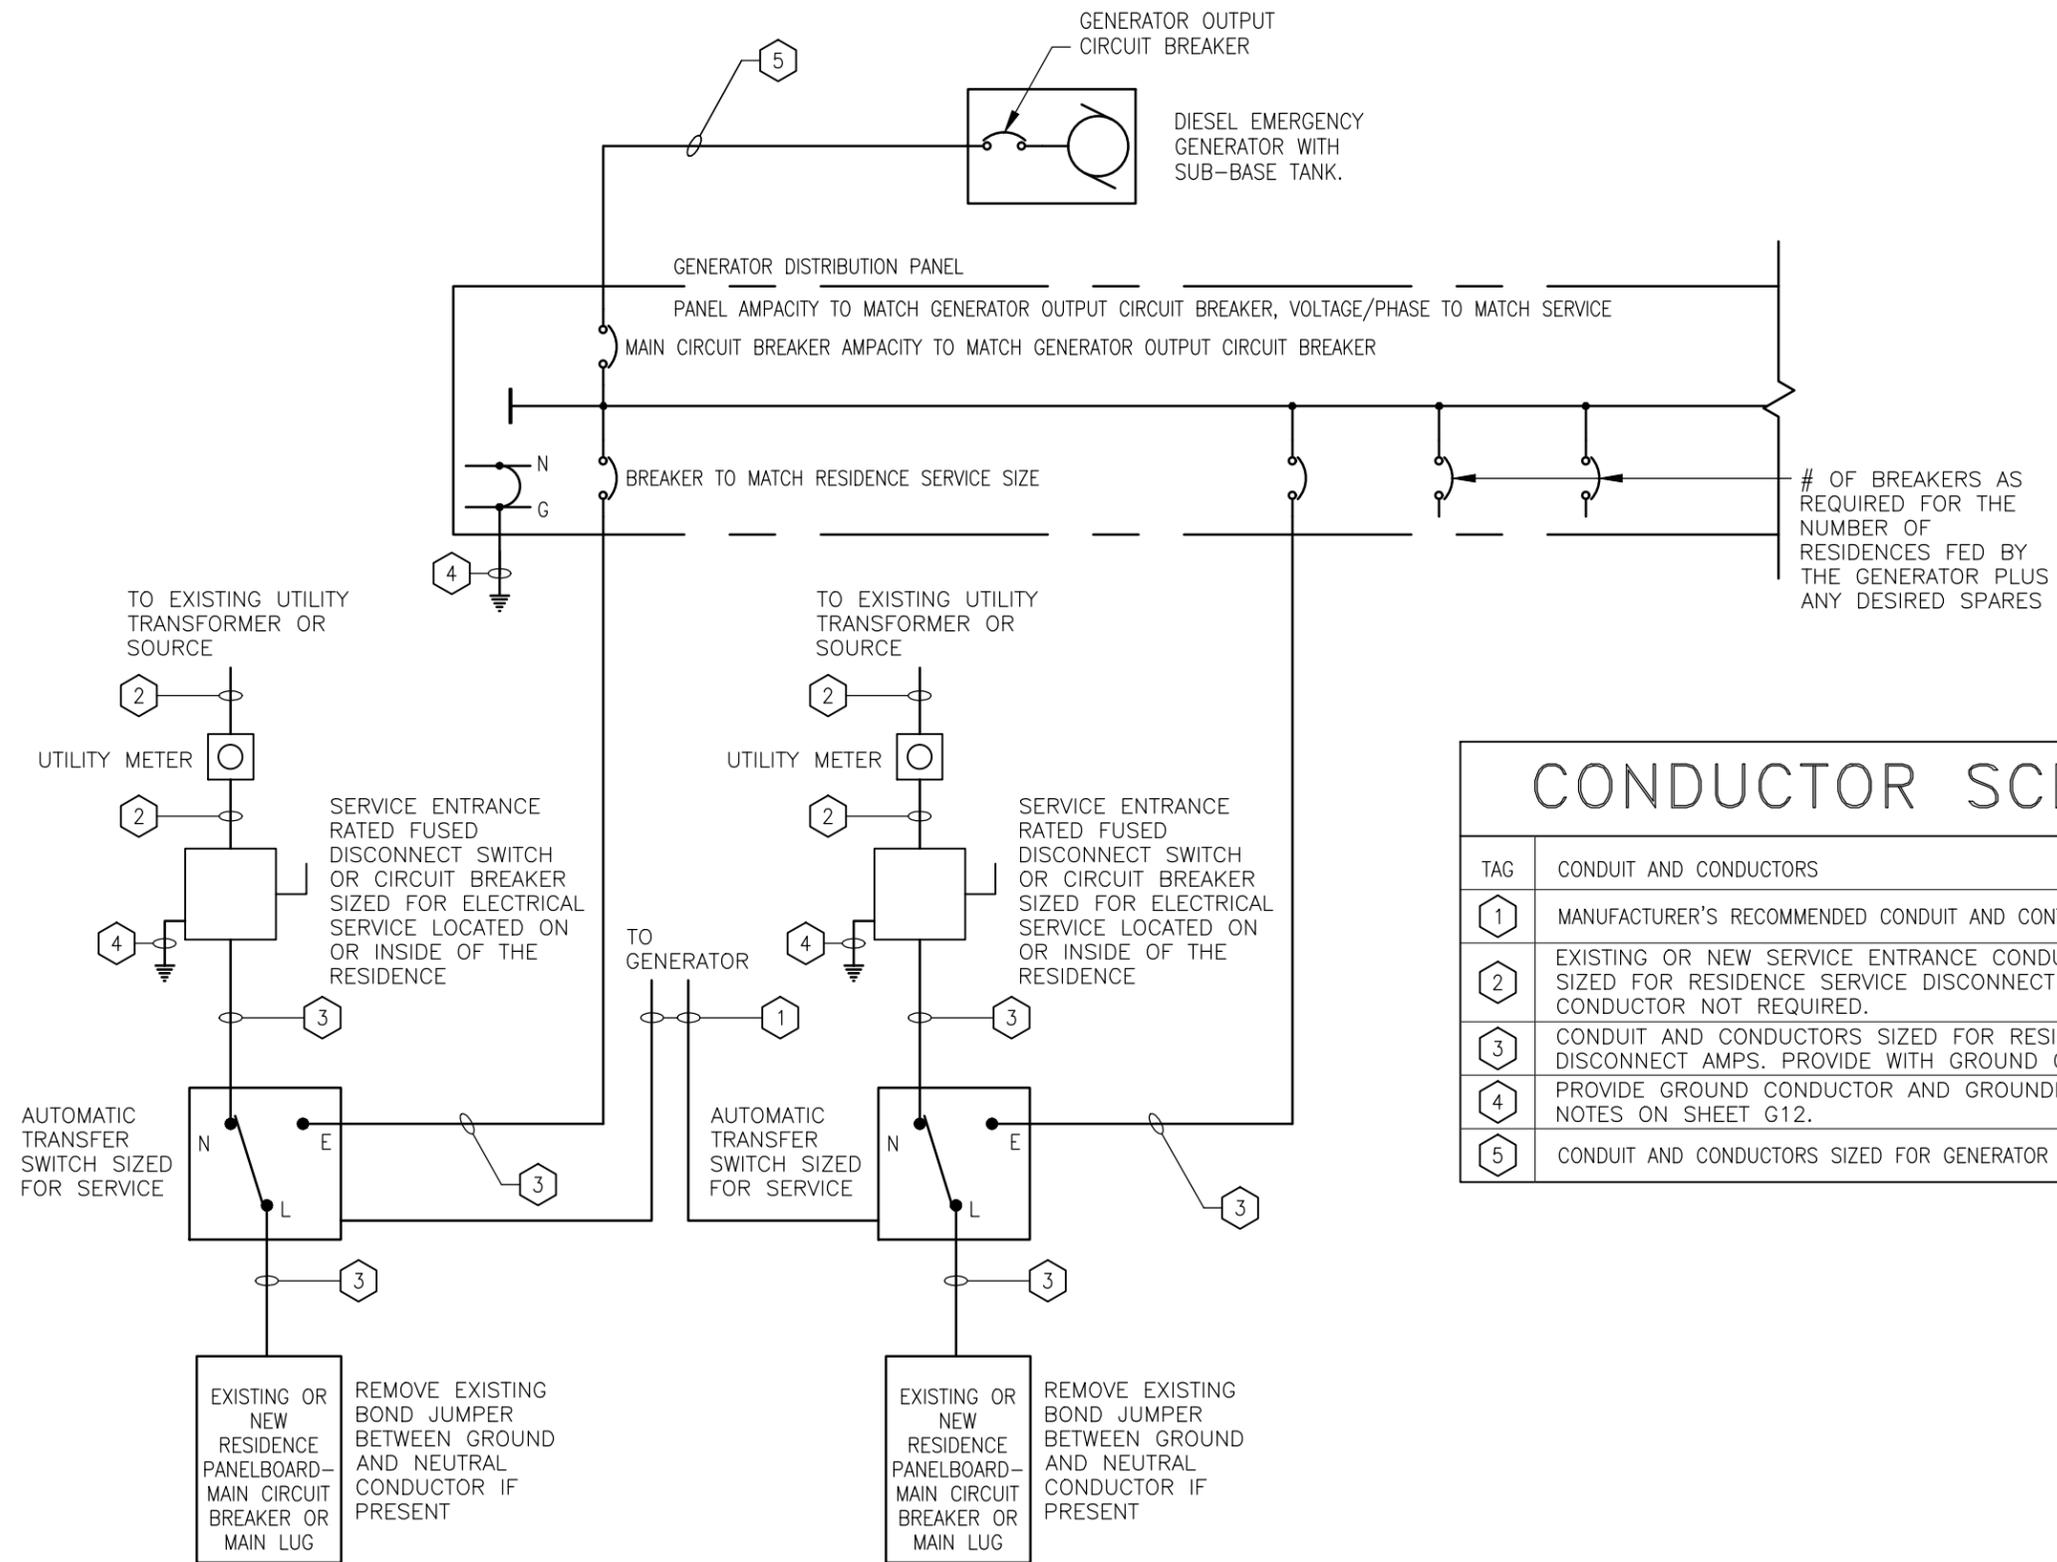

CONDUCTOR SCHEDULE	
TAG	CONDUIT AND CONDUCTORS
1	MANUFACTURER'S RECOMMENDED CONDUIT AND CONTROL CONDUCTORS
2	EXISTING OR NEW SERVICE ENTRANCE CONDUIT AND CONDUCTORS SIZED FOR RESIDENCE SERVICE DISCONNECT AMPS. GROUND CONDUCTOR NOT REQUIRED.
3	CONDUIT AND CONDUCTORS SIZED FOR RESIDENCE SERVICE DISCONNECT AMPS. PROVIDE WITH GROUND CONDUCTOR.
4	PROVIDE GROUND CONDUCTOR AND GROUNDING ELECTRODES PER NOTES ON SHEET G12.
5	CONDUIT AND CONDUCTORS SIZED FOR GENERATOR OUTPUT CIRCUIT BREAKER

1
G11

ELECTRICAL ONE-LINE DIAGRAM - MULTI-FAMILY

SCALE: NO SCALE

Drawing Title

**TYPICAL
ELECTRICAL
ONE-LINE
DIAGRAM—MULTI-
RESIDENCE**

Sheet Number

G11

Date:
9/17/13


ADDITIONAL INSTALLATION NOTES

1. EXTERIOR GENERATORS SHALL BE LOCATED NO CLOSER THAN 2-METERS TO ANY BUILDING. BUILDING OVERHANGS SHALL BE CONSIDERED THE EXTERIOR EDGE OF THE BUILDING. LOCATION OF AN EXTERIOR GENERATOR SHALL BE AS FAR AS PRACTICAL FROM ANY BUILDING SO AS TO MINIMIZE PROBLEMS WITH GENERATOR NOISE AND EXHAUST TO ANY BUILDING INTERIOR. DIRECTION OF EXHAUST SHALL BE POINTED AWAY FROM ANY BUILDING.
2. USE OF PVC CONDUIT BELOW GRADE IS ALLOWED. PROVIDE MAGNETIC LOCATOR TAPE 6" ABOVE PVC CONDUIT BELOW GRADE. CONDUIT ABOVE GRADE SHALL BE RIGID METALLIC CONDUIT OR IMC. LIQUID-TIGHT FLEXIBLE METALLIC CONDUIT MAY BE USED ABOVE GRADE WITHIN THE GENERATOR ENCLOSURE.
3. CONDUIT SHALL BE BURIED A MINIMUM OF 450mm BELOW FINISHED GRADE EXCEPT FOR UNDER DRIVEWAYS OR ROADS, WHERE CONDUIT SHALL BE BURIED A MINIMUM OF 600mm BELOW FINISHED GRADE. RIGID METAL CONDUIT, INTERMEDIATE METAL CONDUIT OR CONCRETE-ENCASED CONDUIT (MINIMUM 75mm COVER ON ALL SIDES) MAY BE BURIED 150mm BELOW FINISHED GRADE EXCEPT FOR UNDER DRIVEWAYS OR ROADS.
4. IN LOCATIONS WHERE THE FROST DEPTH IS BELOW THE BOTTOM OF THE SLAB, LOWER THE BOTTOM OF THE SLAB TO THE FROST DEPTH. PROVIDE AN ADDITIONAL REBAR MATT TO MATCH THE MATTS SHOWN ON THE SLAB DETAILS. THE NUMBER OF REBAR LAYERS SHALL BE DETERMINED BY THE OVERALL FROST DEPTH WITH THE VERTICAL SPACING OR REBAR MATTS 180mm MAXIMUM WHILE MAINTAINING THE TOP AND BOTTOM MATT LOCATIONS AS SHOWN ON THE DETAIL BELOW.
5. FOR SINGLE RESIDENCE GENERATOR INSTALLATIONS, GROUND SERVICE ENTRANCE DISCONNECT SWITCH (OR CIRCUIT BREAKER) WITH TWO 19mm X 3050mm COPPER CLAD STEEL GROUND RODS A MINIMUM OF 3050MM APART WITH TOP OF GROUND ROD 300mm BELOW FINISHED GRADE. BOND GROUND RODS TOGETHER UTILIZING MECHANICAL GROUND CONNECTORS AND 25mm² BARE COPPER GROUND CONDUCTOR BETWEEN THE RODS AND BACK TO THE DISCONNECT SWITCH (OR CIRCUIT BREAKER). BURIED PORTION OF GROUND CONDUCTOR SHALL BE 600mm BELOW FINISHED GRADE. FOR SERVICES UP TO 200-AMPS PROVIDE A 25mm² BARE COPPER GROUND CONDUCTOR AND BOND TO THE METAL COLD WATER LINE (IF AVAILABLE) AND TO BUILDING STEEL (IF AVAILABLE). UTILIZE 35mm² FOR SERVICES UP TO 300-AMPS AND 60mm² FOR SERVICES UP TO 400-AMPS.
6. FOR MULTIPLE RESIDENCE GENERATOR INSTALLATIONS, GROUND DISTRIBUTION PANEL WITH THREE 19mm X 3050mm COPPER CLAD STEEL GROUND RODS A MINIMUM OF 3050MM APART WITH TOP OF GROUND ROD 300mm BELOW FINISHED GRADE. BOND GROUND RODS TOGETHER UTILIZING MECHANICAL GROUND CONNECTORS AND 95mm² BARE COPPER GROUND CONDUCTOR BETWEEN THE RODS AND BACK TO THE DISTRIBUTION PANEL. BURIED PORTION OF GROUND CONDUCTOR SHALL BE 600mm BELOW FINISHED GRADE. IF DISTRIBUTION PANEL IS LOCATED WITHIN A BUILDING, PROVIDE A 95mm² BARE COPPER GROUND CONDUCTOR AND BOND TO THE METAL COLD WATER LINE (IF AVAILABLE) AND TO BUILDING STEEL (IF AVAILABLE).



United States Department of State
OFFICE OF OVERSEAS BUILDINGS OPERATIONS
Washington, D.C.

STANDARD RESIDENTIAL GENERATOR INSTALLATION DETAILS

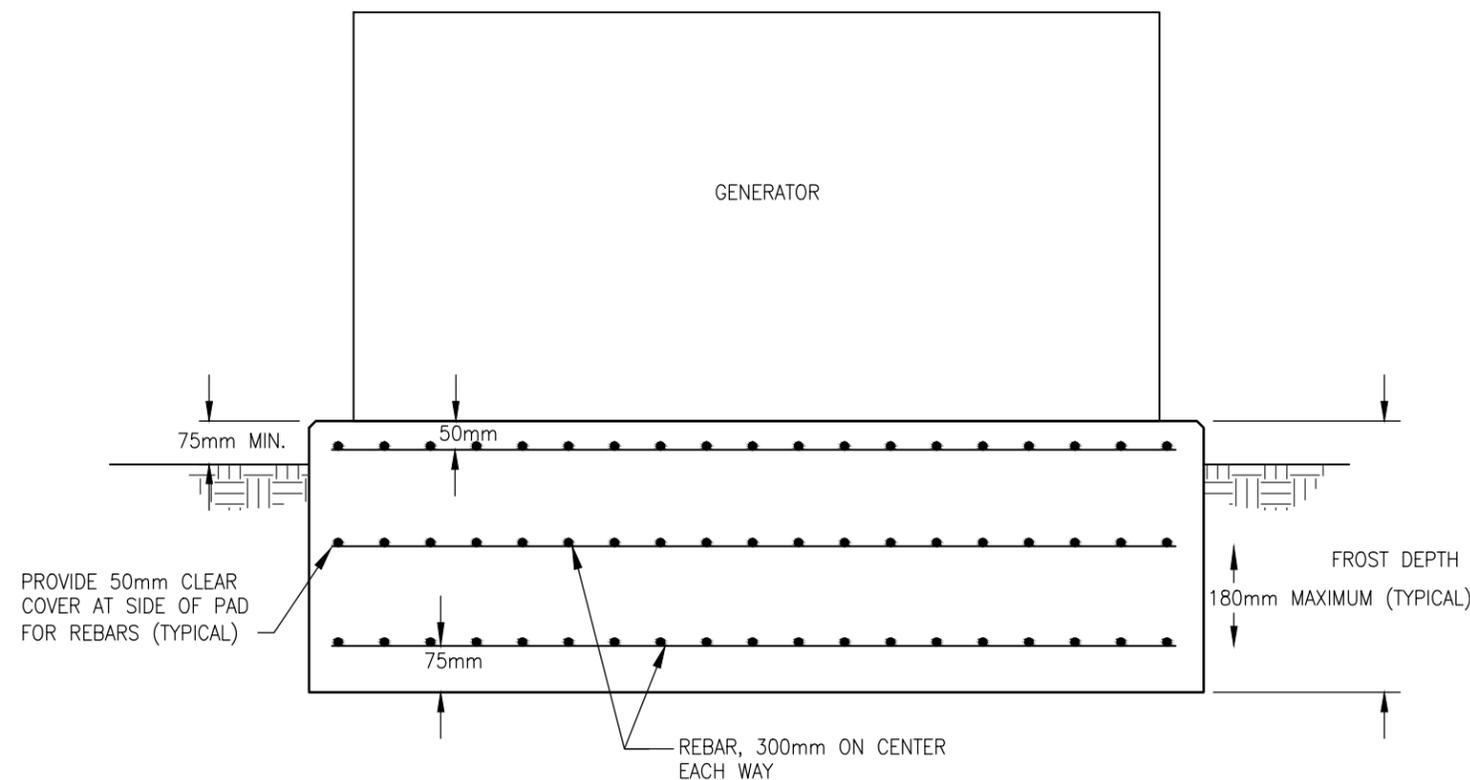

1
G12
DEEPEMED SLAB FOR FROST LINE
 SCALE: NTS

Drawing Title

**ADDITIONAL
INSTALLATION
NOTES AND FROST
SLAB DETAIL**

Sheet Number


G12

Date:
9/17/13



United States Department of State
OFFICE OF OVERSEAS BUILDINGS OPERATIONS
Washington, D.C.

STANDARD RESIDENTIAL
GENERATOR
INSTALLATION DETAILS

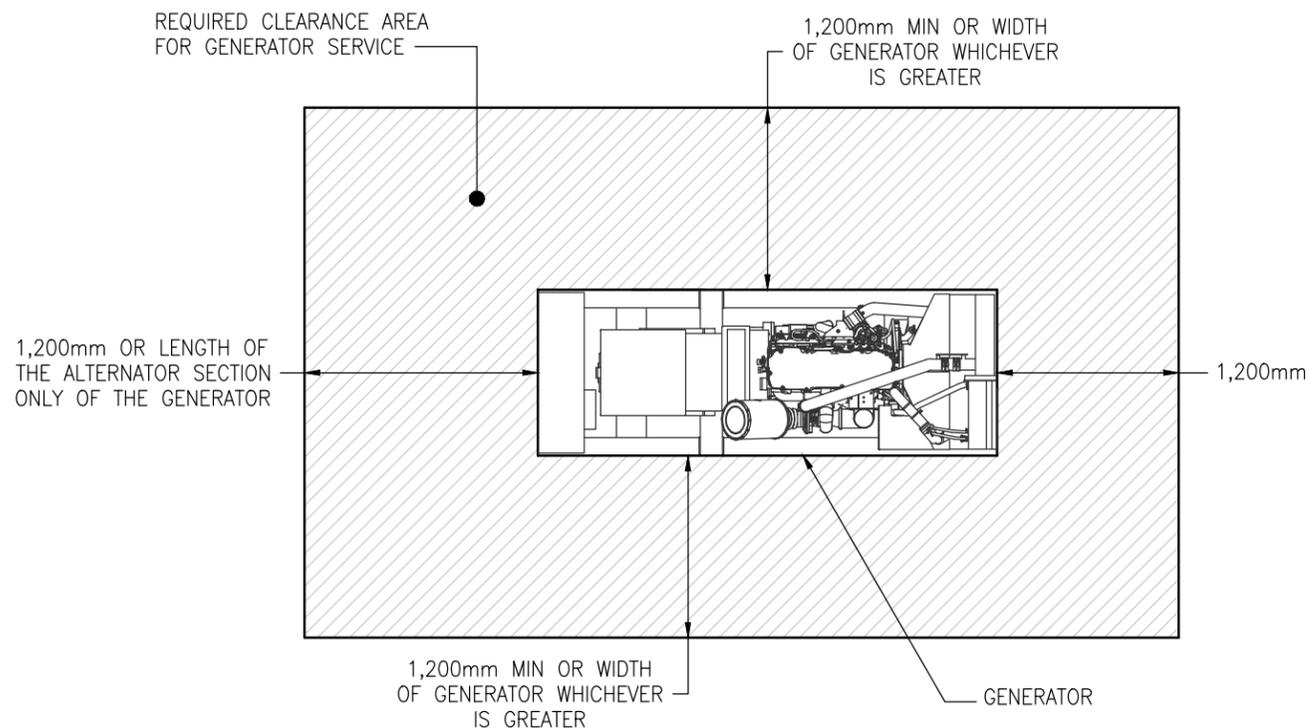

NOTES

1. PROVIDE GENERATOR ROOM ACCESS FOR THE LARGEST GENERATOR COMPONENT TO BE REMOVED. LARGEST COMPONENT IS TYPICALLY THE DIESEL ENGINE.
2. ACCESS SHALL BE PROVIDED THRU A PERMANENT OPENING IN THE GENERATOR ROOM.
3. PROVIDE ADDITIONAL CLEARANCE SPACE FOR OTHER GENERATOR COMPONENTS SUCH AS TRANSFER SWITCHES, BATTERIES, ETC.
4. DO NOT UTILIZE GENERATOR ROOM FOR STORAGE OF ANY TYPE.
5. CLEARANCES NOTED ON THIS SHEET ARE THE MINIMUM REQUIREMENTS FOR MAINTENANCE OF A TYPICAL GENERATOR.
6. REFER TO THE MANUFACTURERS INSTALLATION SHEET FOR THE ACTUAL GENERATOR TO BE INSTALLED FOR ADDITIONAL CLEARANCE REQUIREMENTS.
7. GENERATOR EXHAUST SHALL DISCHARGE A MINIMUM OF 10'-0" FROM ANY BUILDING OPENING.

TYPICAL MATERIAL SPECIFICATIONS FOR GENERATOR DISTRIBUTION SYSTEMS:

EXHAUST FLUE PIPING:
STEEL PIPE, ASTM A 53, TYPE S OR E, GRADE B, SCHEDULE 40, BLACK STEEL WITH WELDED OR FLANGED JOINTS.

EXHAUST FLUE FITTINGS:
WROUGHT CARBON STEEL FITTINGS, SCHEDULE 40, CONFORMING TO ASTM A 234/A 234M AND ASME/ANSI B16.9

EXHAUST FLUE PIPE AND SILENCER INSULATION:
CALCIUM SILICATE, ASTM C 533, TYPE L, PREFORMED PIPE AND EQUIPMENT SECTIONS OF NONCOMBUSTIBLE, INORGANIC, HYDROUS CALCIUM SILICATE WITH A NON-ASBESTOS FIBROUS REINFORCEMENT WITH JACKET RATED FOR 650° C, 100mm THICK MINIMUM.

DUCTWORK AND FITTINGS:
GALVANIZED SHEET METAL, ASTM A 653/A 653M AND HAVING A G90 / Z275 COATING DESIGNATION, LOCK-FORMING QUALITY. CONSTRUCTED IN ACCORDANCE WITH SMACNA HVAC DUCT CONSTRUCTION STANDARDS FOR DUCT PRESSURE CLASS OF 500 Pa, SEAL CLASS C.

FLEXIBLE CONNECTOR (AIRSIDE, INDOOR APPLICATIONS):
GLASS FABRIC COATED WITH SILICONE RUBBER, 540 g/SQ M WITH A TENSILE STRENGTH OF 50 N/mm IN THE WARP AND 32 N/mm IN THE FILLING. RATED FOR AN OPERATING RANGE OF -55 TO 260 DEG C.

EXHAUST BELLOWS:
MULTI-PLY, ASTM A240 STAINLESS STEEL, RATED FOR 100 kPa AT 675° C WITH FLANGED CONNECTIONS.

DIESEL FUEL PIPING:
STEEL PIPE, ASTM A 53, TYPE S OR E, GRADE B, SCHEDULE 40, BLACK STEEL WITH WELDED OR FLANGED JOINTS FOR ABOVE GROUND PIPING GREATER THAN 50mm AND THREADED FOR PIPING 50mm AND LESS.

DIESEL FUEL FITTINGS:
WROUGHT CARBON STEEL WEDLING FITTINGS: SCHEDULE 40, CONFORMING TO ASTM A 234/A 234M AND ASME/ANSI B16.9.
MALLEABLE IRON THREADED FITTINGS: ASME B16.3, CLASS 150, STANDARD PATTERN

1
G13 **TYPICAL GENERATOR CLEARANCE REQUIREMENTS**
SCALE: NONE

Drawing Title

TYPICAL
GENERATOR
CLEARANCE
REQUIREMENTS
AND MATERIAL
SPECIFICATIONS

Sheet Number

G13


Date:
9/17/13



United States Department of State
OFFICE OF OVERSEAS BUILDINGS OPERATIONS
Washington, D.C.

STANDARD RESIDENTIAL
GENERATOR
INSTALLATION DETAILS

RECOMMENDED LOCATION
FOR ROOM INTAKE FOR
PROPER GENERATOR COOLING

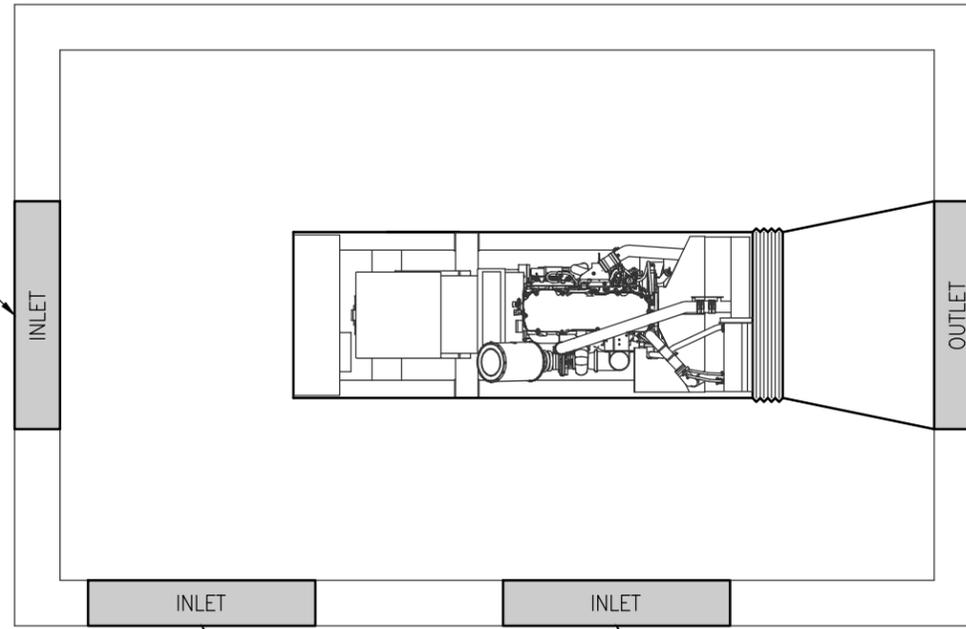

ACCEPTABLE ALTERNATIVE
LOCATION FOR ROOM INTAKE,
TYPICAL EITHER SIDE OF
ROOM

UNACCEPTABLE INLET
LOCATION, TYPICAL EITHER
SIDE OF ROOM

NOTES

1. ROOF MOUNTED INLETS ARE NOT AN ACCEPTABLE ALTERNATIVE INLET LOCATION.
2. UNACCEPTABLE ALTERNATIVE INLET LOCATIONS WILL NOT PROVIDE SUFFICIENT AIRFLOW OVER THE GENERATOR TO MEET THE RADIANT COOLING REQUIREMENTS.
3. INLETS SHALL BE SIZED FOR A MAXIMUM PRESSURE DROP OF 0.06 KPa.
4. OUTLETS SHALL BE SIZED FOR A MAXIMUM PRESSURE DROP OF 0.06 KPa.

1 TYPICAL GENERATOR ROOM PLAN
G14 SCALE: NONE

Drawing Title

RECOMMENDED
LOUVER
LOCATIONS FOR
INDOOR
INSTALLATIONS


Sheet Number

G14

Date:
9/17/13



United States Department of State
OFFICE OF OVERSEAS BUILDINGS OPERATIONS
Washington, D.C.

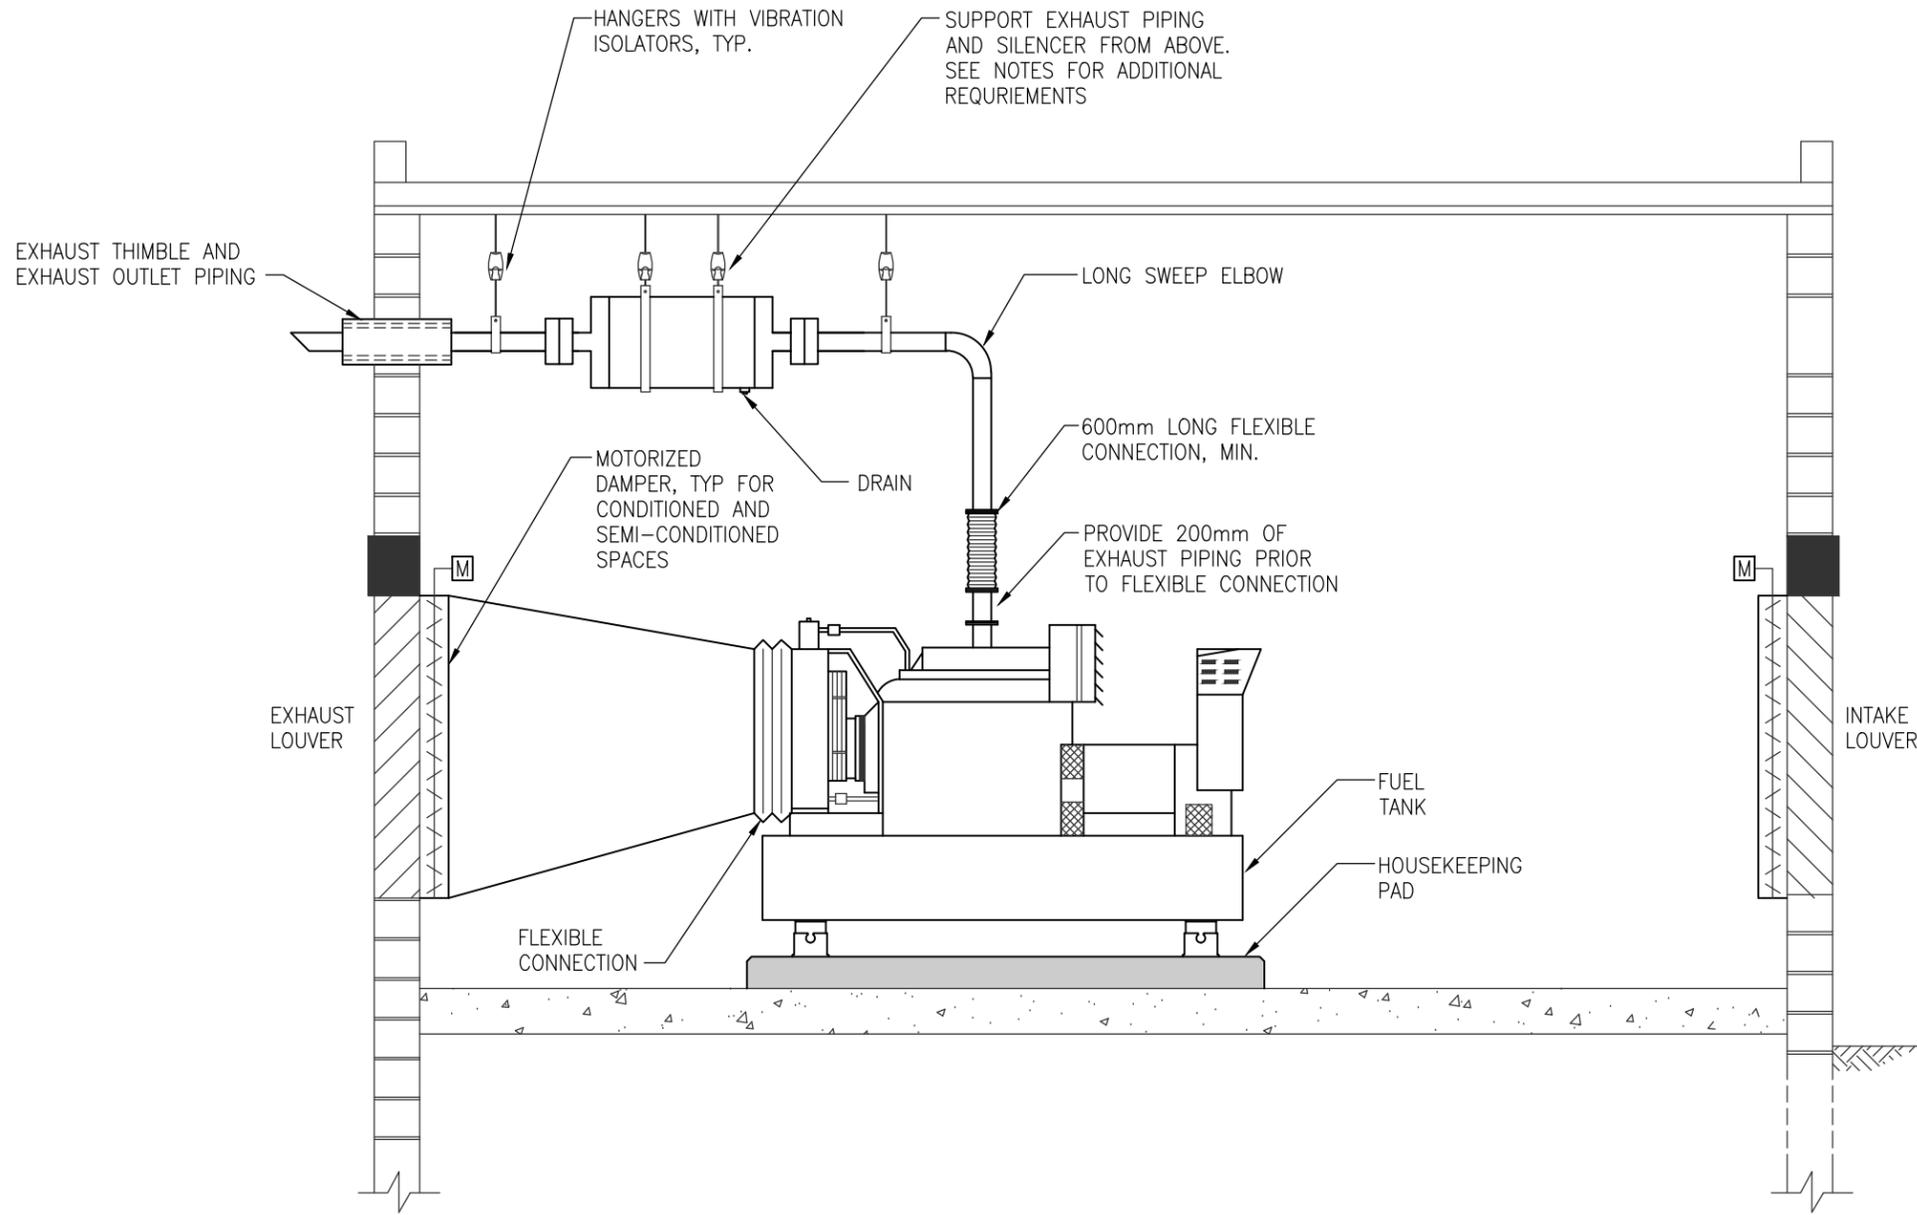

NOTES

1. PITCH EXHAUST PIPING A MINIMUM OF 0.5% SLOPE AWAY FROM THE GENERATOR TO MINIMIZE CONDENSATION RETURN TO THE ENGINE.
2. TRANSITIONS SHALL BE MADE WITH LONG SWEEP ELBOWS ONLY.
3. ALL FLUE PIPING SHALL HAVE A MINIMUM OF 12" CLEARANCE FROM COMBUSTIBLE MATERIALS.
4. WEIGHT OF THE EXHAUST SYSTEM SHALL NOT BEAR UPON THE GENERATOR EXHAUST CONNECTION/S OR BY ANY COMPONENT OF THE GENERATOR.
5. EXHAUST OUTLETS SHALL BE LOCATED A MINIMUM OF 10'-0" FROM OUTSIDE AIR INTAKES OR BUILDING OPENINGS AND IN ACCORDANCE WITH ALL LOCAL CODES AND REQUIREMENTS.
6. EXHAUST PIPING AND SILENCERS SHALL BE INSULATED TO PROVIDE PERSONAL PROTECTION AND MINIMIZE HEAT GAIN INTO THE GENERATOR ROOM
7. FAIL OPEN DAMPERS WILL BE UTILIZED FOR VENTILATION ISOLATION WITH SPRING RETURNS. DAMPERS SHALL BE CONNECTED TO NORMAL POWER ONLY.

1
G15 **GENERAL REQUIREMENTS ELEVATION**
SCALE: NONE

STANDARD RESIDENTIAL
GENERATOR
INSTALLATION DETAILS

Drawing Title

GENERAL INDOOR
GENERATOR
INSTALLATION
REQUIREMENTS


Sheet Number

G15


Date:
9/17/13



United States Department of State
OFFICE OF OVERSEAS BUILDINGS OPERATIONS
Washington, D.C.

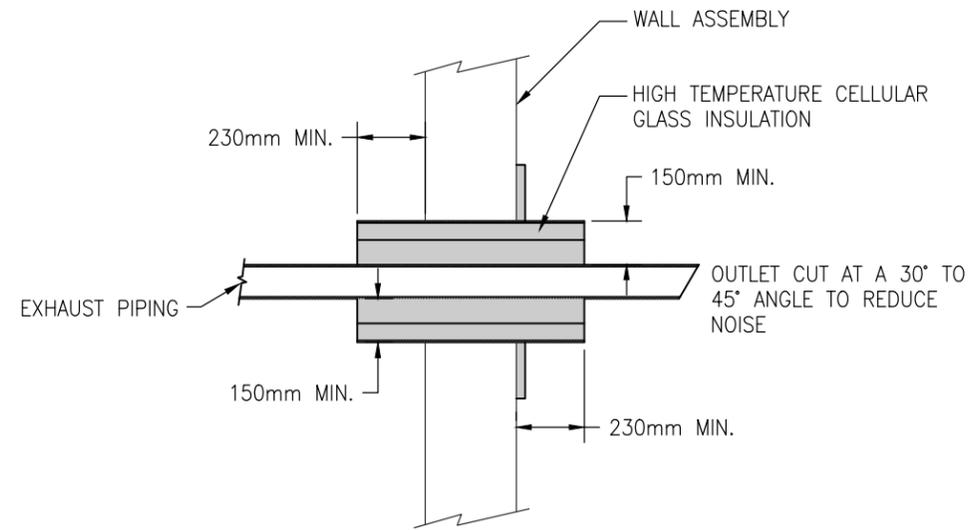

SECTION A-A: WALL PENETRATION

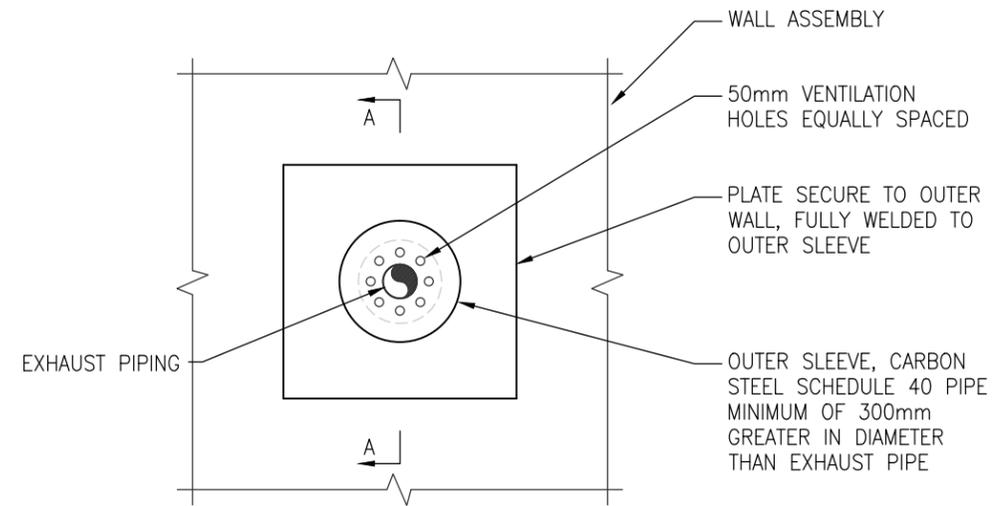

1 THIMBLE DETAIL
G16 SCALE: NONE

**STANDARD RESIDENTIAL
GENERATOR
INSTALLATION DETAILS**

Drawing Title

**WALL EXHAUST
PENETRATION
DETAILS**

Sheet Number


G16

Date:
9/17/13




United States Department of State
OFFICE OF OVERSEAS BUILDINGS OPERATIONS
Washington, D.C.

STANDARD RESIDENTIAL
GENERATOR
INSTALLATION DETAILS

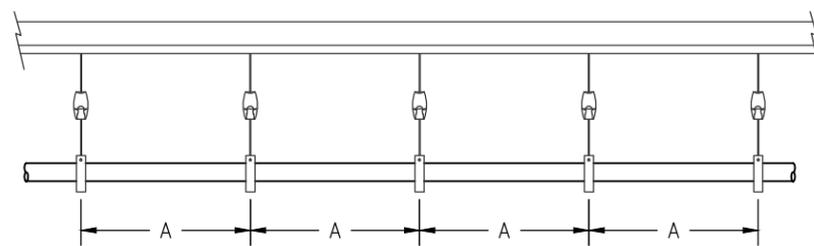

EQUAL SPACING BETWEEN SUPPORTS

IMPROPER SPACING

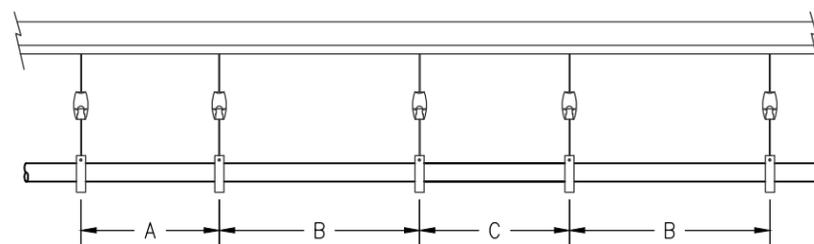

UNEQUAL SPACING BETWEEN SUPPORTS

PROPER SPACING

**GENERAL EXHAUST PIPING
HANGER SPACING REQUIREMENTS**

1
G17

SCALE: NONE

TABLE 1 – MAXIMUM HORIZONTAL SUPPORT SPACING	
NOMINAL PIPE DIAMETER	MAXIMUM SPACING (M)
50mm	4.0
65mm	4.3
80mm	4.6
90mm	4.9
100mm	5.2
125mm	5.8
150mm	6.4
200mm	7.3

NOTES

- HANGERS AND SUPPORTS SHALL COMPLY WITH ANSI/MSS SP-69 AND SP-58.
- SPACING SHALL NOT EXCEED THAT MAXIMUM ALLOWABLE SUPPORT REQUIREMENTS LISTED IN ANSI/MSS SP-69 AND SP-58 LISTED IN TABLE 1.
- TABLE 1 VALUES ARE BASED UPON STANDARD WEIGHT CARBON STEEL PIPING ONLY AND DOES NOT INCLUDE THE WEIGHT OF PIPING APPURTENANCES OR CHANGES IN DIRECTION THAT MAY REQUIRE ADDITIONAL SUPPORTS.
- TABLE 1 VALUES ARE BASED UPON NON-THRUST LOADS WHICH MAY REQUIRE ANCHORS AND GUIDES TO PROVIDE A FULLY RESTRAINED SYSTEM.
- UNEQUAL HANGER SPACING WILL MINIMIZE THE POTENTIAL FOR RESONANCE AND VIBRATION IN THE EXHAUST SYSTEM.
- PROVIDE TRANSVERSE AND LONGITUDINAL SEISMIC HANGERS WHERE REQUIRED BY PROJECT LOCATION. SEE SHEET G21 FOR TYPICAL SEISMIC HANGER DETAILS.

Drawing Title

**GENERAL EXHAUST
PIPING HANGER
REQUIREMENTS**

Sheet Number

G17

Date:
9/17/13



United States Department of State
OFFICE OF OVERSEAS BUILDINGS OPERATIONS
Washington, D.C.

STANDARD RESIDENTIAL
GENERATOR
INSTALLATION DETAILS

**TABLE 1 – ESTIMATED EXHAUST FLOW RATE
AT 80 Pa/M PRESSURE DROP**

	NOMINAL PIPE DIAMETER							
	50mm	65mm	80mm	90mm	100mm	125mm	150mm	200mm
MAXIMUM EXHAUST AIRFLOW (M ³ /MIN)	4.25	7.35	11.25	19.75	16.10	42.35	64.90	115.70

GENERAL NOTES:

- MAXIMUM AIRFLOW IS BASED UPON A BACK PRESSURE OF 80 Pa/M THRU A SCHEDULE 40 CARBON STEEL PIPE.
- VALUES PROVIDED IN THIS TABLE ARE ESTIMATED.

TABLE 2 – EQUIVALENT LENGTHS FOR FITTINGS

TYPE OF FITTING	NOMINAL PIPE DIAMETER							
	50mm	65mm	80mm	90mm	100mm	125mm	150mm	200mm
90° STANDARD ELBOW	1.6	1.9	2.3	2.9	3.0	4.0	4.6	6.4
90° MEDIUM RADIUS ELBOW	1.4	1.6	2.1	2.4	2.7	3.4	4.0	5.5
90° LONG RADIUS ELBOW	1.1	1.3	1.6	1.8	2.1	2.6	3.0	4.3
45° ELBOW	0.7	0.9	1.1	1.3	1.4	1.8	2.2	1.8
TEE,SIDE INLET OR OUTLET	3.0	3.7	4.9	5.5	6.1	7.6	9.4	13
450mm FLEXIBLE TUBE	0.9	0.9	0.9	0.9	0.9	0.9	0.9	0.9
600mm FLEXIBLE TUBE	1.2	1.2	1.2	1.2	1.2	1.2	1.2	1.2

GENERAL NOTES:

- VALUES REPRESENT EQUIVALENT METERS OF STRAIGHT PIPE.

EXHAUST BACK PRESSURE CALCULATIONS:

- ANY EXTENDED EXHAUST SYSTEM SHALL BE DESIGNED BY A REGISTERED PROFESSIONAL ENGINEER.
- EXHAUST PIPE SHALL BE SIZED TO MEET THE MINIMUM AND MAXIMUM BACK PRESSURE LIMITS FOR THE GENERATOR (7.5 KPa MEETS OR IS LESS THAN ALL GENERATORS' MAXIMUM BACK PRESSURE REQUIREMENT). REFER TO THE MANUFACTURER'S LITERATURE FOR THE EXACT BACK PRESSURE LIMITATIONS FOR THE GENERATOR TO BE INSTALLED.
- THE FOLLOWING IS A GENERAL OUTLINE TO DETERMINE THE ANTICIPATED ENGINE BACK PRESSURE FOR ESTIMATING PURPOSES:
 - DETERMINE THE ENGINE EXHAUST FLOW RATE IN M³/MIN.
 - DETERMINE THE EXHAUST BACK PRESSURE ASSOCIATED WITH THE SILENCER. THIS INFORMATION SHOULD BE OBTAINED FROM THE SILENCER MANUFACTURER OR PROVIDER FOR THE ENGINE'S RATED EXHAUST FLOW RATE.
 - DETERMINE THE TOTAL LINEAR LENGTH OF EXHAUST PIPE.
 - DETERMINE THE TOTAL NUMBER OF FITTINGS AND TYPES.
 - COMPARE THE GENERATOR EXHAUST FLOW RATE TO THE FLOW RATES IN TABLE 2, ESTIMATED EXHAUST FLOW RATE AT 80 Pa/M AND SELECT THE PIPE DIAMETER WITH THE NEXT HIGHER FLOW RATE.
 - MULTIPLY THE NUMBER OF FITTINGS TIMES THE EQUIVALENT LENGTHS LISTED IN TABLE 2 FOR THE SELECTED EXHAUST DIAMETER.
 - TOTAL THE LINEAR LENGTH OF EXHAUST PIPE AND SUM OF THE EQUIVALENT PIPE LENGTH ASSOCIATED WITH THE FITTINGS.
 - MULTIPLY THE TOTAL EQUIVALENT PIPE LENGTH DETERMINED IN ITEM G TIMES 80 Pa/M.
 - ADD THE BACK PRESSURE CALCULATED IN ITEM H TO THE SILENCER BACK PRESSURE THIS IS YOUR TOTAL ESTIMATED ENGINE BACK PRESSURE AND SHOULD NOT BE GREATER THAN THE BACK PRESSURE RATING OF THE ENGINE.

Drawing Title

**ENGINE BACK
PRESSURE
CALCULATION
INFORMATION**

Sheet Number


G18

Date:
9/17/13



United States Department of State
OFFICE OF OVERSEAS BUILDINGS OPERATIONS
Washington, D.C.

STANDARD RESIDENTIAL
GENERATOR
INSTALLATION DETAILS

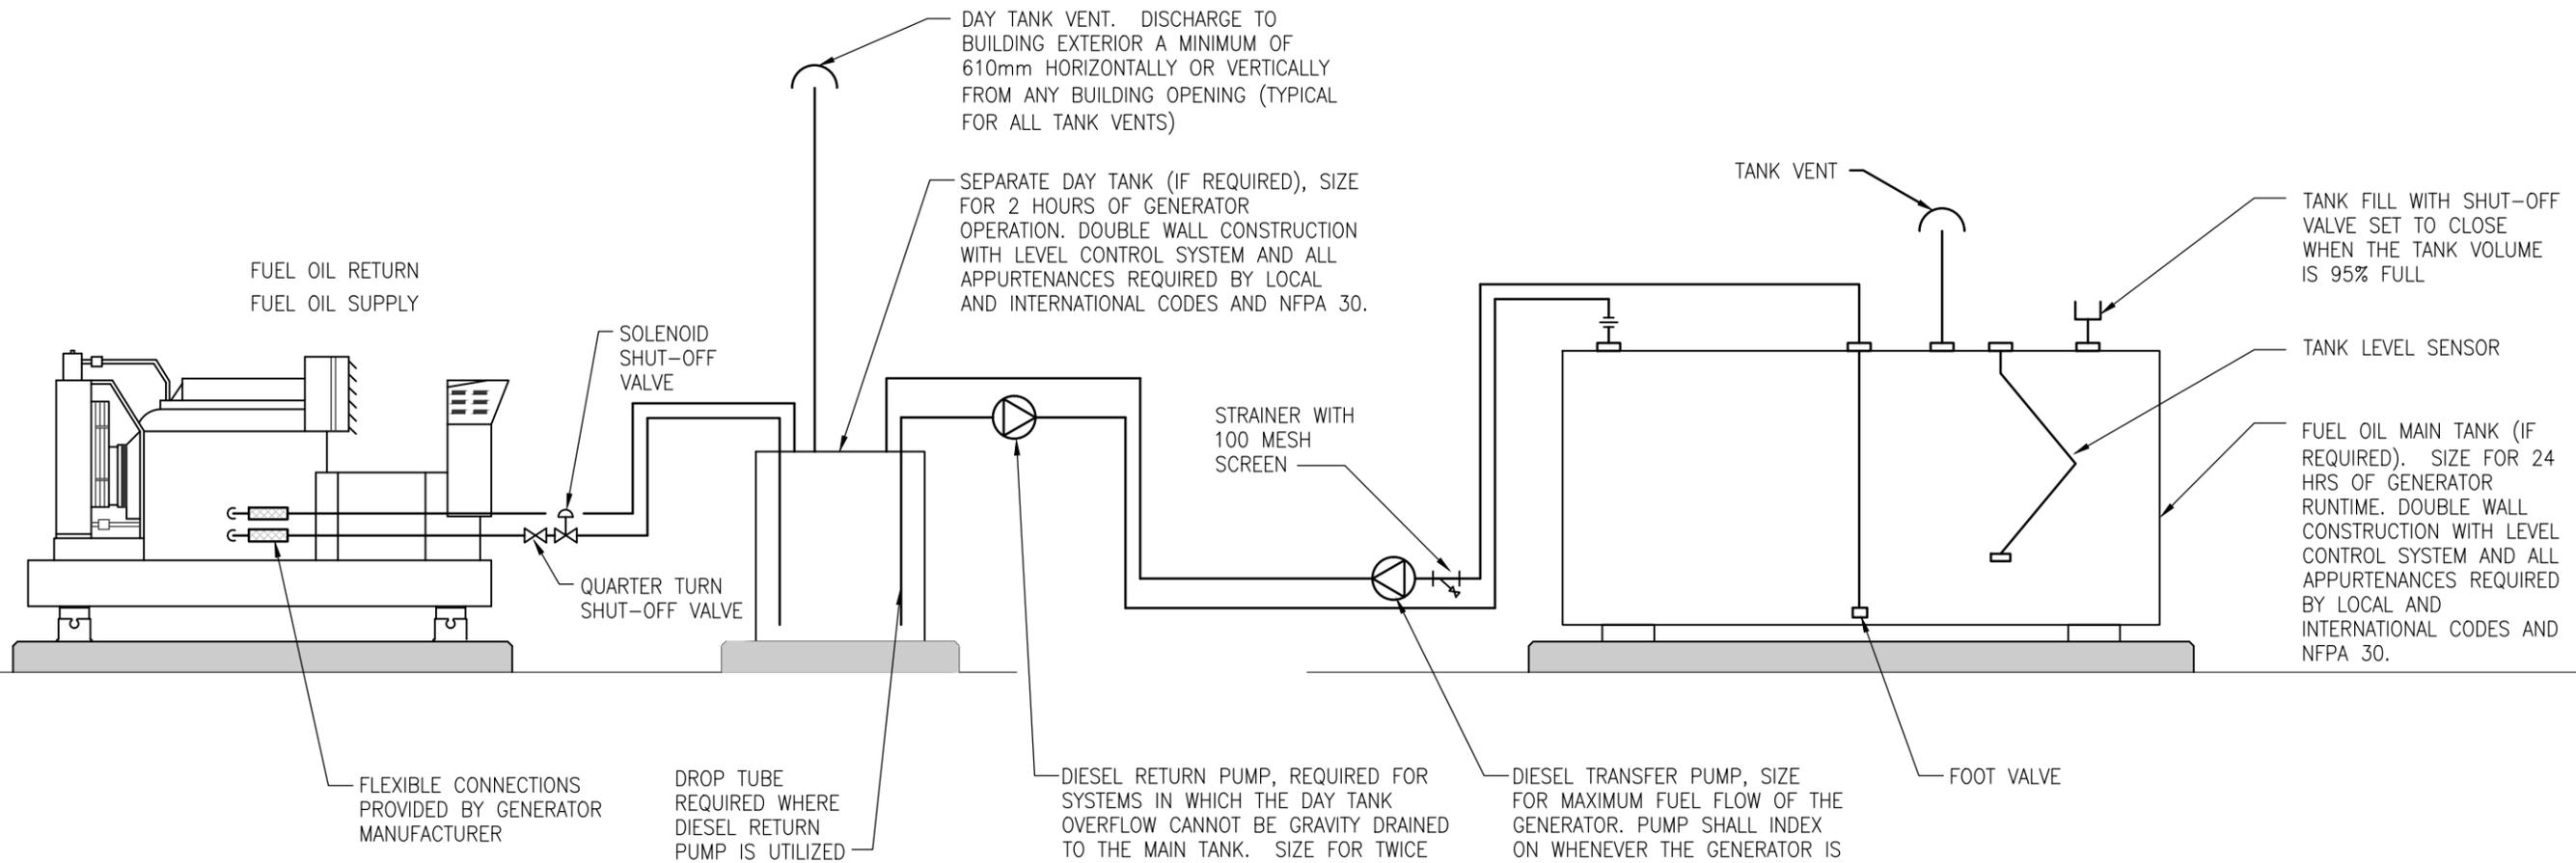

SCHEMATIC NOTES

1. THE DIESEL FLOW SCHEMATIC PROVIDES THE GENERAL REQUIREMENTS FOR A REMOTE MAIN TANK AND INTERIOR DAY TANK FOR THE DIESEL GENERATOR. ALTHOUGH THIS SCHEMATIC PROVIDES THE GENERAL ARRANGEMENT AND REQUIREMENTS, IT DOES NOT INDICATE ALL COMPONENTS REQUIRED TO COMPLY WITH LOCAL OR INTERNATIONAL CODES OR ELEVATION CHANGES BETWEEN THE COMPONENTS. RECOMMEND THAT IF A REMOTE MAIN TANK AND DAY TANK ARE REQUIRED BY THE PROJECT THAT THE FUEL OIL SYSTEM BE DESIGNED BY A PROFESSIONAL ENGINEER.
2. TYPICAL GENERATORS ARE PROVIDED WITH AN 18-24-HOUR SUB-BASE TANK THAT CAN BE UTILIZED AS THE DAY TANK SHOWN HERE.
3. THE DAY TANK SHALL BE ARRANGED SO THAT THE FUEL LEVEL DOES NOT EXCEED MAXIMUM HEIGHT ABOVE THE FUEL INJECTORS AS INDICATED BY THE GENERATOR MANUFACTURER.
4. THE DAY TANK LOW LEVEL SHALL NOT BE LOWER THAN THE LIFT HEIGHT OF THE GENERATOR'S FUEL OIL PUMP.
5. PROVIDE 20 MESH STRAINER BETWEEN THE MAIN TANK AND FUEL OIL TRANSFER PUMP.
6. FUEL SUPPLY AND RETURN PIPING SHALL BE HEAT TRACED IN COLD WEATHER ENVIRONMENTS.
7. FUEL OIL RETURN PIPING SHALL NOT INCLUDE SHUT-OFF VALVES.
8. PIPING FROM THE DAY TANK TO THE GENERATOR SHALL BE ARRANGED TO AVOID THE POTENTIAL OF AIR ENTRAINMENT.
9. SUPPORT FUEL OIL PIPING IN ACCORDANCE WITH TABLE 1

TABLE 1 - MAXIMUM HORIZONTAL SUPPORT SPACING	
NOMINAL PIPE DIAMETER	MAXIMUM SPACING (M)
32mm AND LESS	2.1
40mm	2.7
50mm	3.0
65mm	3.4
80mm	3.7
100mm	4.3
150mm	5.2
200mm	5.8

TABLE 1 NOTES

1. HANGERS AND SUPPORTS SHALL COMPLY WITH ANSI/MSS SP-69 AND SP-58.
2. SPACING SHALL NOT EXCEED THAT MAXIMUM ALLOWABLE SUPPORT REQUIREMENTS LISTED IN ANSI/MSS SP-69 AND SP-58 LISTED IN TABLE 1.
3. TABLE 1 VALUES ARE BASED UPON STANDARD WEIGHT CARBON STEEL PIPING ONLY AND DOES NOT INCLUDE THE WEIGHT OF PIPING APPURTENANCES OR CHANGES IN DIRECTION THAT MAY REQUIRE ADDITIONAL SUPPORTS.
4. PROVIDE TRANSVERSE AND LONGITUDINAL SEISMIC HANGERS WHERE REQUIRED BY PROJECT LOCATION. SEE SHEET G21 FOR TYPICAL SEISMIC HANGER DETAILS.

Drawing Title

**GENERAL DIESEL
FUEL PIPING
SCHEMATIC FOR
INDOOR
APPLICATIONS**

Sheet Number

G19

Date:
9/17/13



United States Department of State
OFFICE OF OVERSEAS BUILDINGS OPERATIONS
Washington, D.C.

STANDARD RESIDENTIAL
GENERATOR
INSTALLATION DETAILS


Drawing Title

TYPICAL SEISMIC
FUEL OIL AND
EXHAUST PIPING
HANGER DETAILS


Sheet Number

G20

Date:
9/17/13

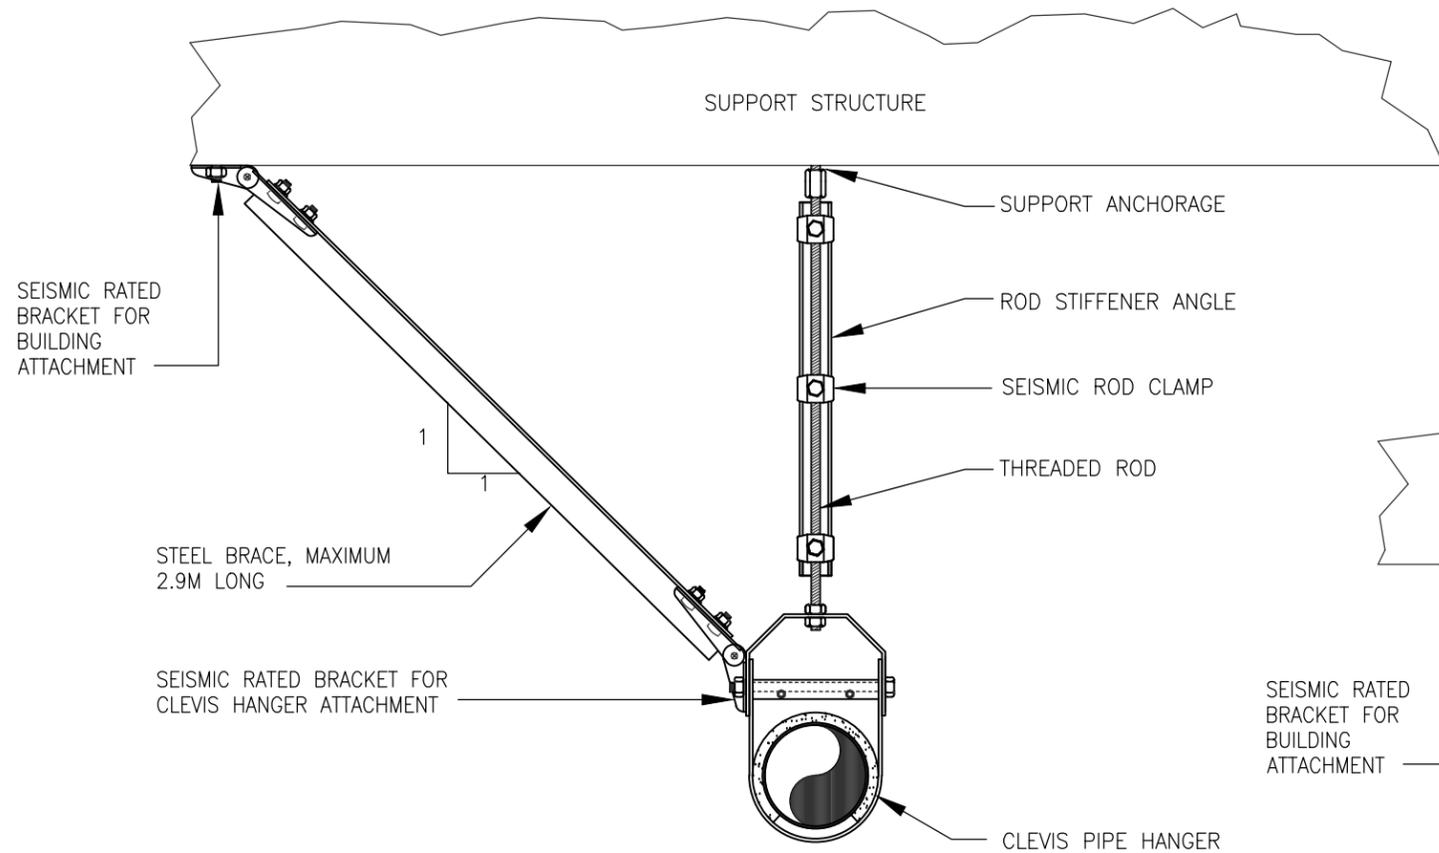

1 TYPICAL TRANSVERSE SEISMIC HANGER
G20 SCALE: NONE

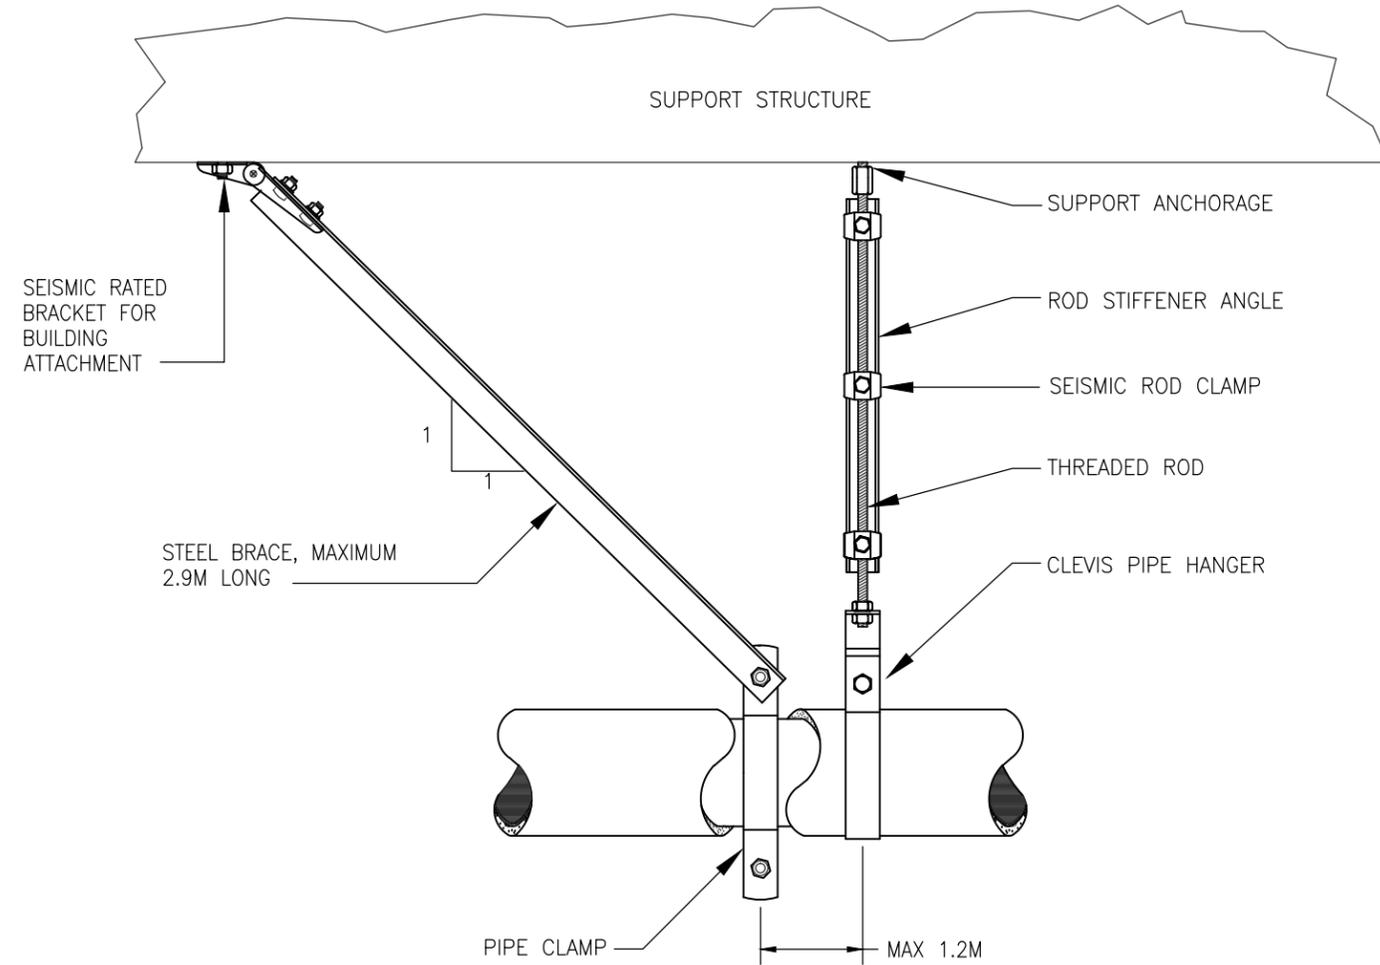

2 TYPICAL LONGITUDINAL SEISMIC HANGER
G20 SCALE: NONE

NOTES

1. LOCATIONS AND SIZING OF SEISMIC HANGERS AND THEIR COMPONENTS SHALL BE DETERMINED BY A REGISTERED ENGINEER BASED UPON THE SEISMIC REQUIREMENTS FOR THE PROJECT LOCATION.
2. THE IMPORTANCE FACTOR FOR THE EMERGENCY GENERATOR SYSTEM SHALL BE CONSIDERED AS AN $I_p = 1.0$ UNLESS INDICATED OTHERWISE.